



IGS ARE AND SHALL REMAIN THE PROPERTY OF ARMENARC. NO PART THEREOF	NO.	ISSUED) FOR:	
PARI				
≥				
NEMENARC				
7 OF 7				
OPERI				
분 불				
EMAIN				
HALL				
AND S				
SARE	JOB NO.:		20034	
9				

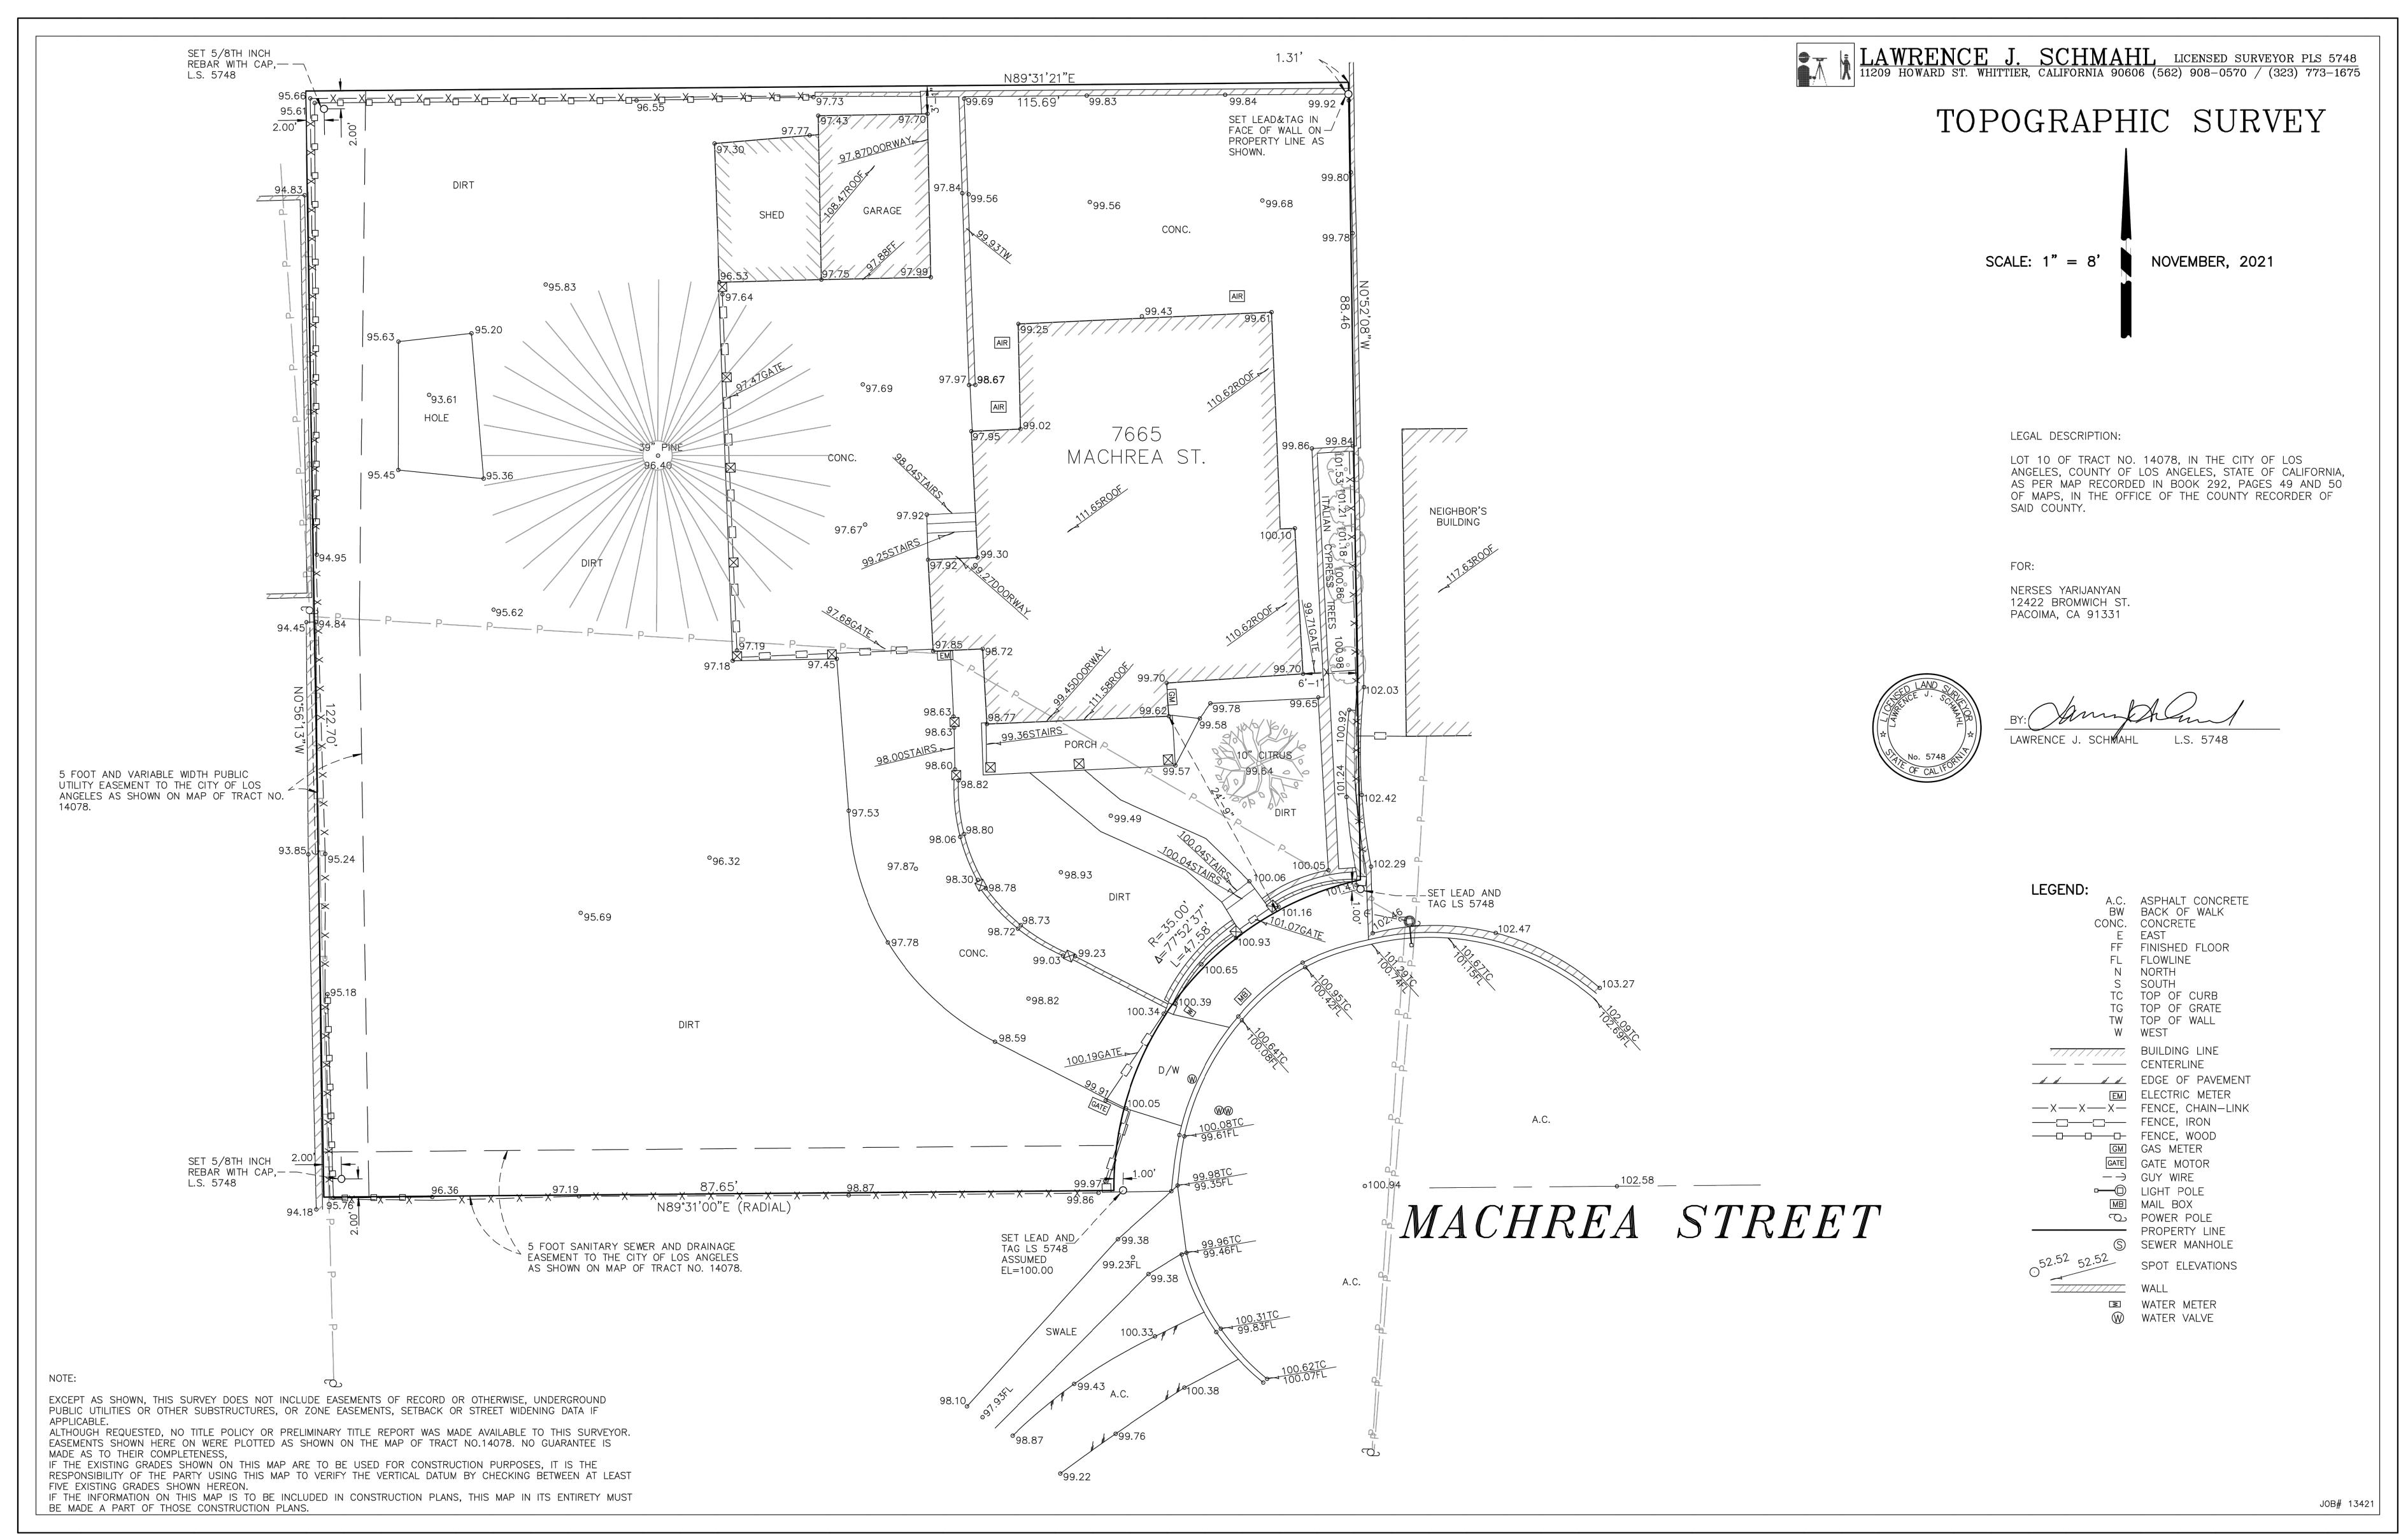

SURVERY





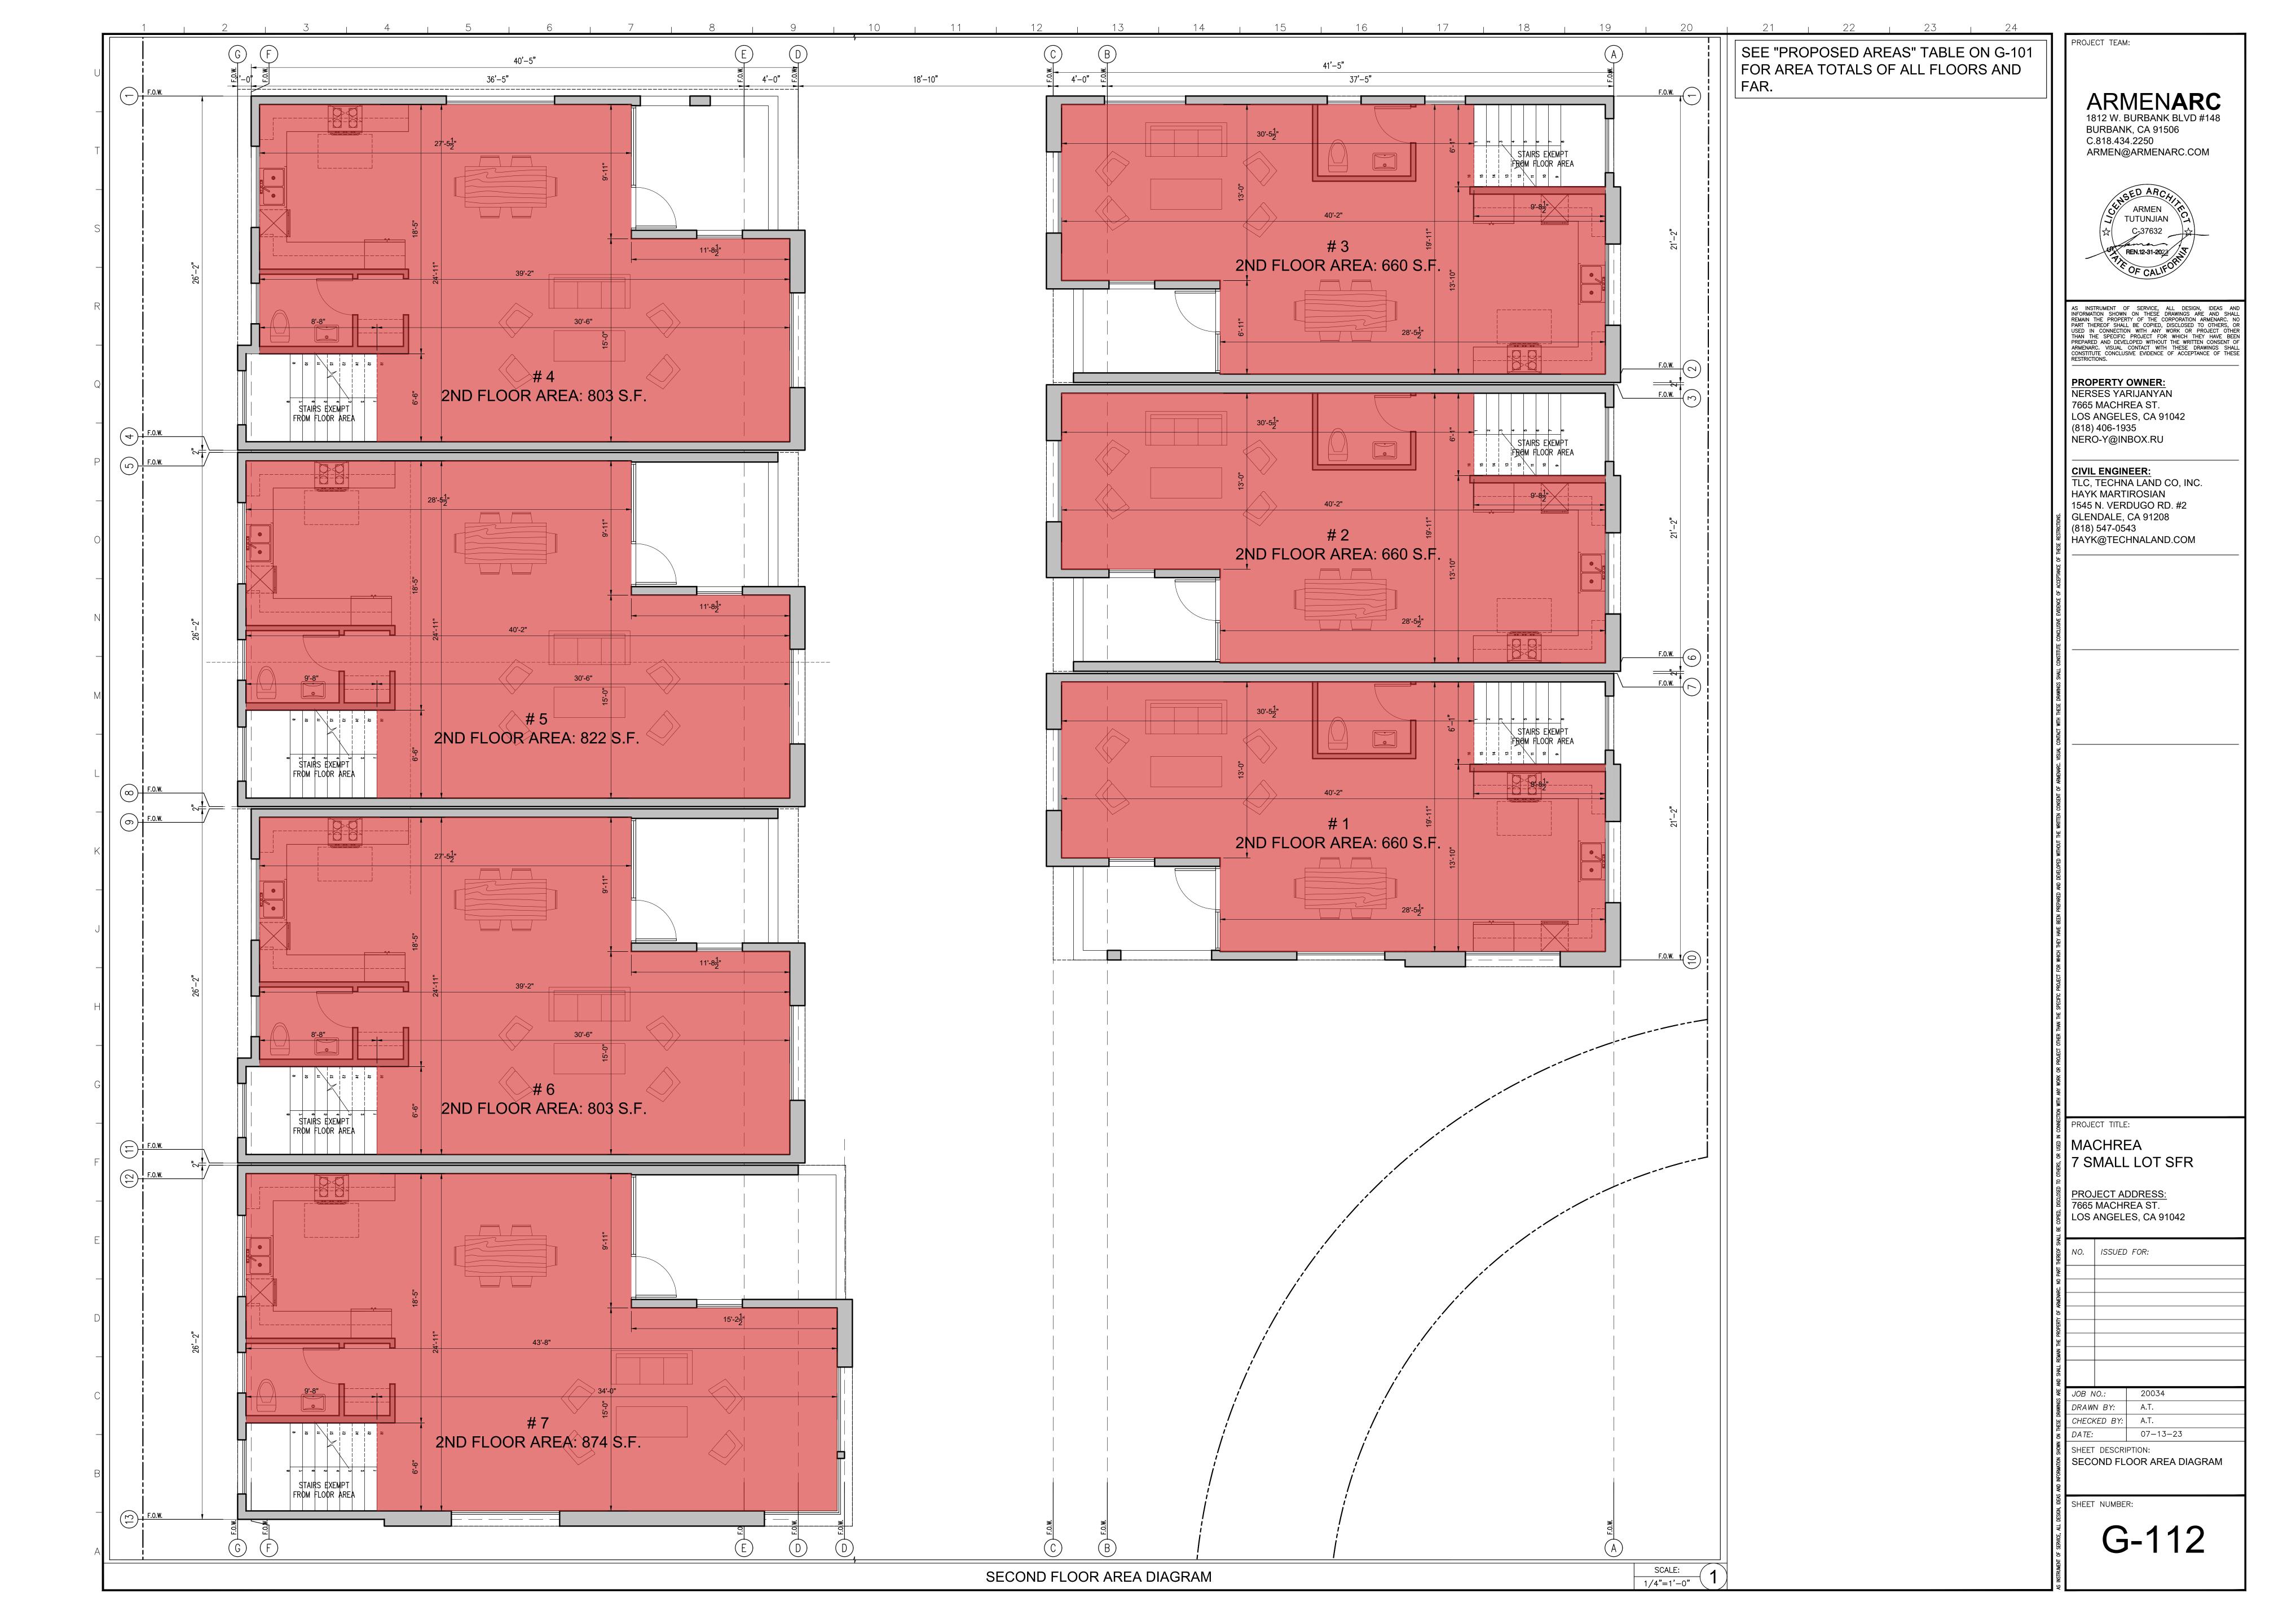



ZIMAS INTRANET MACHREA AVE ORD 71 Address: 7665 W MACHREA ST Tract: TR 14078 APN: 2558002015 Block: None General Plan: Low Medium I Residential PIN #: 204B197 218 Lot: 10 Arb: None ZONING DETERMINATION LETTER:

NOTES TO CONTRACTOR:

- THE CONTRACTOR SHALL MAINTAIN PROPER ACCESS FOR FIRE DEPARTMENT VECHICLES AND EQUIPMENT AT ALL TIMES. ANY CHANGES MADE TO FIRE DEPARTMENT ACCESS ROUTES SHALL BE REVIEWED BY FIRE DEPARTMENT AUTHORITIES HAVING JURISDICTION PRIOR TO CHANGING
- 2. THE CONTRACTOR SHALL SECURE AND PAY FOR ALL NECESSARY PERMITS AND NOTIFY THE PROPER AUTHORITIES HAVING JURISDICTION
- OVER THE WORK PRIOR TO STARTING. SAID PERMITS AND CERTIFICATIONS SHALL BE KEPT ON THE SITE AT ALL TIMES. PRIOR TO START OF WORK, THE CONTRACTOR SHALL CAREFULLY INSPECT AND VERIFY ALL CONDITIONS SHOWN ON THE CONTRACT
- AFTER SUCH DISCOVERY, UNLESS AUTHORIZED BY THE OWNER, SHALL BE DONE AT THE CONTRACTOR'S RISK. 4. THE CONTRACTOR SHALL VERIFY AND CHECK ALL DIMENSIONS AND ELEVATIONS AT THE PROJECT SITE AND THE OVERALL CORECTNESS OF THESE DOCUMENTS BY STUDYING THEM THROUGHLY AND IF THERE ARE ANY QUESTIONS TO CONTACT THE OWNER OR DESIGNER
- IMMEDIATELY FOR CLARIFICATION PRIOR TO THE BIDDING AND BEFORE THE START OF CONSTRUCTION. THE CONTRACTOR SHALL NOT INTERRUPT EXISTING UTILITIES SERVING EXISTING FACILITIES, EXCEPT WHEN AUTHORIZED IN WRITING BY THE
- PROPERTY OWNER. PROVIDE TEMPORARY SERVICES DURING CONSTRUCTION. 6. THE WORK SHALL INCLUDE ALL DEMOLITION AND REMOVALS NOT SPECIFICALLY INDICATED ON DRAWINGS BUT NECESSARY FOR THE
- COMPLETION OF THE WORK.
- THE CONTRACTOR SHALL COORDINATE ANY AND ALL REQUIREMENTS FOR OFF SITE IMPROVEMENTS INCLUDING, BUT NOT LIMITED TO SIDEWALKS, DRIVEWAYS, CURBS, GUTTERS, UTILITIES, ETC. OFF-SITE IMPROVEMENTS SHALL MEET THE REQUIREMENTS OF THE AUTHORITY HAVING JURISDICTION.
- 8. THE CONTRACTOR SHALL PROVIDE PROTECTIVE BARRICADES WHERE REQUIRED DURING CONSTRUCTION.
- THE CONTRACTOR SHALL KEEP ALL EXITS READILY ACCESSIBLE AND UNOBSTRUCTED AT ALL TIMES.
- 10. DO NOT SCALE DRAWINGS. USE DIMENSIONS INDICATED. DIMENISONS HAVE PREFERENCE OVER SCALE.
- 11. WHEN A DETAIL IS IDENTIFIED AS TYPICAL, THE CONTRACTOR SHALL APPLY THIS DETAIL TO EVERY LIKE CONDITION WHETHER OR NOT THE REFERENCE IS REPEATED IN EVERY INSTANCE.
- 12. THE SIZES, LOCATION FOR MOUNTINGS AND ATTACHMENTS AND LOCATIONS OF UTILITY CONNECTIONS FOR EACH ITEM OF EQUIPMENT SHOWN ON THE DRAWINGS ARE FOR ILLUSTRATION ONLY. ALL CAN VARY FROM MANUFACTURER TO MANUFACTURER AND ARE DEPENDENT ON THE EXACT MANUFACTURER'S MODEL FURNISHED. THE CONTRACTOR SHALL PROVIDE AND COORDINATE EXACT DIMENSIONS RELATING TO THE SIZE OF EACH ITEM OF EQUIPMENT, THE LOCATIONS OF ALL FITTINGS AND ATTACHMENTS FOR EACH EQUIPMENT AND FOR ALL UTILITY CONNECTIONS TO EACH ITEM OF EQUIPMENT.
- 13. THE CONTRACTOR SHALL PROVIDE AND COORDINATE THE EXACT DIMENSIONS, SIZES AND POSITIONS OF ALL OPENINGS IN FLOOR, ROOF AND WALL CONSTRUCTION NECESSARY FOR THE INSTALLATION OF THE WORK.
- 14. PROVIDE LABELS ON DOORS, FRAMES AND OTHER ASSEMBLIES AT OPENINGS IN FIRE RATED CONSTRUCTION.
- 15. THE INTENT OF THE DRAWINGS AND SPECIFICATIONS IS TO EXECUTE THE WORK IN ACCORDANCE WITH TITLE 24, CALIFORNIA CODE OF REGULATIONS. SHOULD ANY CONDITIONS DEVELOP NOT COVERED BY THE CONTRACT DOCUMENTS WHEREIN THE FINISHED WORK WILL NOT COMPLY WITH SAID TITLE 24. CALIFORNIA CODE OF REGULATIONS. CONTRACTOR SHALL NOTIFY THE OWNER BEFORE PROCEEDING WITH THE WORK.THE GENERAL CONTRACTOR SHALL CONTACT THE DEPARTMERNT OF BUILDING AND SAFETY AND VERIFY THAT THEY ARE NOW THE CONTRACTOR OF RECORD FOR THIS PROJECT. THEY SHALL PROVIDE THE DEPARTMENT OF BUILDING AND SAFETY WITH PROOF OF CURRENT WORKERS COMPENSATION INSURANCE AND SHALL ASSUME FULL RESPONCIBILITY FOR SUCH COVRAGE. THIS IS TO BE DONE BY THE GENERAL CONTRACTOR PRIOR TO THE START OF CONSTRUCTION.
- 16. ALL WORK SHALL BE DONE IN AN APPROVED WORKMANLIKE MANNER.
- 17. APPROVALS BY BUILDING INSPECTOR SHALL NOT CONSTITUTE AUTHORITY TO DEVIEATE FROM THIS PLANS AND SPECIFICATIONS.
- 18. THE CONTRACTORS SHALL BE REQUIRED TO MAINTAIN WORKMAN'S COMPENSATION INSURANCE AS PROVIDED BY CALIFORNIA LAW. ALSO PUBLIC LIABILITY AND PROPERTY DAMAGE INSURANCE OF ADEQUATE COVRAGE, FIRE INSURANCE, THEFT AND VANDALISM INSURANCE DURING CONSTRUCTION UP TO THE CERTIFICATE OF OCCUPANCY ISSUED AND/OR OWNER'S SATISFACTION OF COMPLETION OF CONTRACT.
- 19. FOR GENERAL AND PLAN LAYOUT, CONSTRUCTION DETAILS, ETC. REFER ONLY TO THE ATCHITECTURAL SHEETS WHICH SHALL TAKE PRECEDENCE OVER ANY OTHER DRAWINGS. UNLESS OTHERWISE NOTED, ALL DIMENSIONS ARE SHOWN AS FOLLOWS: FACE OF WALL AT MASONRY, INDICATED FACE OF STUD, CENTER LINE, GRID LINE, TOP OF CONCRETE SLAB OR FOUNDATION, TOP OF PLYWOOD, ETC. DRAWINGS SHALL NOT BE SCALED TO DERMINE ANY DIMENSIONS, REFER ONLY TO WRITTEN INFORMATION AND DETAIL DRAWINGS.

GENERAL NOTES: GENERAL NOTES - (CONT'D):

FIRE PROTECTION:

- THE BUILDING SHALL BE EQUIPPED WITH AN AUTOMATIC RESIDENTIAL FIRE SPRINKLER SYSTEM IN ACCORDANCE WITH SECTION R313.3 OR NFPA13D. (R313, 12.21A17(d))
- 3. THE SPRINKLER SYSTEM SHALL BE APPROVED BY PLUMBING DIVISION PRIOR TO INSTALLATION.
 - AN APPROVED SMOKE ALARMS SHALL BE INSTALLED IN EACH SLEEPING ROOM & HALLWAY OR AREA GIVING ACCESS TO A SLEEPING ROOM, AND ON EACH STORY AND BASEMENT FOR DWELLINGS WITH MORE THAN ONE STORY. SMOKE ALARMS SHALL BE INTERCONNECTED SO THAT ACTUATION OF ONE ALARM WILL ACTIVATE ALL THE ALARMS WITHIN THE INDIVIDUAL DWELLING UNIT. IN NEW CONSTRUCTION SMOKE ALARMS SHALL RECEIVE THEIR PRIMARY POWER SOURCE FROM THE BUILDING WIRING AND SHALL BE EQUIPPED WITH BATTERY BACKUP AND LOW BATTERY SIGNAL.
- CARBON MONOXIDE ALARM IS REQUIRED PER (420.6.R315) AN APPROVED CARBON MONOXIDE ALARM SHALL BE INSTALLED IN DWELLING UNITS AND IN SLEEPING UNITS WITHIN WHICH FUEL-BURNING APPLIANCES ARE INSTALLED AND IN DWELLING UNITS THAT HAVE ATTACHED GARAGES. CARBON MONOXIDE ALARM SHALL BE PROVIDED OUTSIDE OF EACH SEPARATE DWELLING UNIT SLEEPING AREA IN THE IMMEDIATE VICINITY OF THE BEDROOM(S) AND ON EVERY LEVEL OF A DWELLING UNIT INCLUDING BASEMENTS. (R315)
- A FIRE ALARM (VISUAL & AUDIBLE) SYSTEM IS REQUIRED. THE ALARM SYSTEM MUST BE APPROVED BY THE FIRE DEPARTMENT AND ELECTRICAL PLAN CHECK PRIOR TO INSTALLATION (LAMC 57.122)

- ALL SHOWER ENCLOSURES, REGARDLESS OF SHAPE, SHALL HAVE A MINIMUM FINISHED INTERIOR AREA OF NOT LESS THAT 1024 SQUARE INCHES (0.66m²) AND SHALL BE CAPABLE OF ENCOMPASSING A 30 INCH DIAMETER (0.76 m) CIRCLE. THE MINIMUM AREA AND DIMENSIONS SHALL BE MAINTAINED TO A POINT 70 INCHES (1.8m) ABOVE THE SHOWER DRAIN OUTLET. (CPC
- A MIN. 12" SQ. ACCESS PANEL TO THE BATHTUB TRAP SLIP JOINT CONNECTION IS REQUIRED. (CPC SEC. 405.2).

BUILDING ENVELOPE:

- GLAZING IN THE FOLLOWING LOCATIONS SHALL BE SAFETY GLAZING CONFORMING TO THE HUMAN IMPACT LOADS OF SECTION R308.3 (SEE EXCEPTIONS) (R308.4): A. FIXED AND OPERABLE PANELS OF SWINGING, SLIDING AND BIFOLD DOOR ASSEMBLIES.
- GLAZING IN INDIVIDUAL FIXED OR OPERABLE PANEL ADJACENT TO A DOOR WHERE THE NEAREST VERTICAL EDGE IS WITHIN a 24-INCH ARC OF THE DOOR IN A CLOSED POSITION AND WHOSE BOTTOM EDGE IS LESS THAN 60 INCHES ABOVE THE FLOOR OR WALKING SURFACE. GLAZING IN AN INDIVIDUAL FIXED OR OPERABLE PANEL THAT MEETS ALL OF THE FOLLOWING
- CONDITIONS: EXPOSED AREA OF AN INDIVIDUAL PANE GRATER THAN 9 SQUARE FEET. BOTTOM EDGE LESS THAN 18 INCHES ABOVE THE FLOOR.

MEASURED VERTICALLY ABOVE ANY STANDING OR WALKING SURFACE.

- TOP EDGE GREATER THAN 36 INCHES ABOVE FLOOR. ONE OR MORE WALKING SURFACE WITHIN 36 INCHES HORIZONTALLY OF THE GLAZING.
- GLAZING IN GUARDS AND RAILINGS.

STAIRS AND RAMPS.

- GLAZING IN ENCLOSURES FOR OR WALLS FACING HOT TUBS. WHIRLPOOLS. SAUNAS. STEAM ROOMS. BATHTUBS AND SHOWERS WHERE THE BOTTOM EDGE OF THE GLAZING IS LESS THAN 60 INCHES
- GLAZING IN WALLS AND FENCES ADJACENT TO INDOOR OR OUTDOOR SWIMMING POOLS, HOT TUBS AND SPAS WHERE THE BOTTOM EDGE OF THE GLAZING IS LESS THAN 60 INCHES ABOVE A WALKING SURFACE AND WITHIN 60 INCHES, MEASURED HORIZONTALLY AND IN A STRAIGHT LINE, OF THE WATER'S EDGE.
- GLAZING WHERE THE BOTTOM EXPOSED EDGE OF THE GLAZING IS LESS THAN 36 INCHES ABOVE THE PLANE OF THE ADJACENT WALKING SURFACE OF STAIRWAYS, LANDINGS BETWEEN FLIGHTS OF
- GLAZING ADJACENT TO THE LANDING AT THE BOTTOM OF A STAIRWAY WHERE THE GLAZING IS LESS THAN 36 INCHES ABOVE THE LANDING AND WITHIN A 60 INCH HORIZONTAL ARC LESS THAN 180 DEGREES FROM THE BOTTOM TREAD NOSING (R304.2)
- BUILDINGS SHALL HAVE APPROVED ADDRESS NUMBERS, BUILDING NUMBERS OR APPROVED BUILDING IDENTIFICATION PLACED IN A POSITION THAT IS PLAINLY LEGIBLE AND VISIBLE FROM THE STREET OR ROAD FRONTING THE PROPERTY. (R319.1)
- PROTECTION OF WOOD AND WOOD BASED PRODUCTION FROM DECAY SHALL BE PROVIDED IN THE LOCATIONS SPECIFIED PER SECTION R317.1 BY THE USE OF NATURALLY DURABLE WOOD OR WOOD THAT IS PRESERVATIVE—TREATED IN ACCORDANCE WITH AWPA U1 FOR THE SPECIES, PRODUCT,
- PROVIDE ANTI-GRAFFITI FINISH WITHIN THE FIRST 9 FEET MEASURED FROM GRADE, AT EXTERIOR WALLS AND DOORS. EXCEPTION: MAINTENANCE OF BUILDING AFFIDAVIT IS RECORDED BY THE OWNER TO COVENANT AND AGREE WITH THE CITY OF LOS ANGELES TO REMOVE ANY GRAFFITI WITHIN 7-DAYS OF THE GRAFFITI BEING APPLIED. (6306)

PRESERVATIVE AND END USE. PRESERVATIVES SHALL BE LISTED IN SECTION 4 OF AWPA U1.

LOTS SHALL BE GRADED TO DRAIN SURFACE WATER AWAY FROM THE FOUNDATION WALLS WIHT A MINIMUM FALL OF 6 INCHES WITHIN THE FIRST 10 FEET. (R401.3)

SMALL LOT SUBDIVISION NOTE:

FOR SMALL LOT SUBDIVISON PROJECTS, NO DEMOLITION, GRADING, BUILDING PERMIT OR CERTIFICATE OF OCCUPANCY SHALL BE ISSUED UNLESS THE DIRECTOR OF PLANNING HAS REVIEWED THE APPLICATION AND DETERMINED THAT THE SMALL LOT SUBDIVISION PROJECT COMPLIES WITH THE CITY PLANNING COMMISSIONS SMALL LOT DESIGN STANDARDS PER LAMC 12.22 C27.A.2.

GENERAL NOTES:

- ALL CONSTRUCTION SHALL COMPLY WITH THE 2022 EDITION OF THE CBC, CMC, CPC, AND CEC AS ADOPTED AND AMENDED BY THE STATE OF CALIFORNIA IN TITLE 24 CCR AND THIS JURISDICTION.
- SEPARATE PERMITS MAY BE REQUIRED FOR MECHANICAL, ELECTRICAL, PLUMBING, SHORING, GRADING, DEMOLITION, RETAINING WALLS, SIGNS AND FIRE SPRINKLER SYSTEMS.
- ALL PROPERTY LINES, EASEMENTS, AND EXISTING BUILDINGS HAVE BEEN INDICATED ON THE SITE
- A SECURITY FENCE SHALL BE PROVIDED AROUND THE CONSTRUCTION AREA THAT SHALL BE
- INSTALLED PRIOR TO EXCAVATION AND/OR FOUNDATION TRENCHING. (BMC 9-1-1-3302.3)
- WATER SHALL BE PROVIDED ON THE SITE AND USED TO CONTROL DUST.
- THE FINISH GRADE SHALL SLOPE A MIN. OF 5%, OR 6", TO A POINT 10 FT FROM BUILDING FOUNDATION, OR TO AN APPROVED ALTERNATE METHOD OF DIVERTING WATER AWAY FROM THE

TEMPORARY TOILET FACILITIES SHALL BE PROVIDED ON SITE. (BMC 9-1-1-3305)

- FOUNDATION. SWALES SHALL SLOPE A MINIMUM OF 2%. (CRC R401.3) THE TOP OF THE EXTERIOR FOUNDATION SHALL EXTEND ABOVE THE ELEVATION OF THE STREET
- GUTTER A MINIMUM OF 12" PLUS 2%. (CRC R403.1.7.3) THE CONSTRUCTION SHALL NOT RESTRICT A FIVE-FOOT CLEAR AND UNOBSTRUCTED ACCESS TO ANY WATER OR POWER DISTRIBUTION FACILITIES (POWER POLES, PULL-BOXES, TRANSFORMERS, VAULTS. PUMPS. VALVES. METERS. APPURTENANCES. ETC.) OR TO THE LOCATION OF THE
- CONSTRUCTION DELAYS AND/OR ADDITIONAL EXPENSES. AN APPROVED SEISMIC GAS SHUTOFF VALVE WILL BE INSTALLED ON THE FUEL GAS LINE ON THE DOWN STREAM SIDE OF THE UTILITY METER AND BE RIGIDLY CONNECTED TO THE EXTERIOR OF THE BUILDING OR STRUCTURE CONTAINING THE FUEL GAS PIPING. (PER ORDINANCE 170,158)

HOOK-UP. THE CONSTRUCTION SHALL NOT BE WITHIN TEN FEET OF ANY POWER LINES -

WHETHER OR NOT THE LINES ARE LOCATED ON THE PROPERTY. FAILURE TO COMPLY MAY CAUSE

SEPARATE PLUMBING PERMIT IS REQUIRED. PLUMBING FIXTURES ARE REQUIRED TO BE CONNECTED TO A SANITARY SEWER OR TO AN

APPROVED SEWAGE DISPOSAL SYSTEM. (R306.3)

- KITCHEN SINKS, LAVATORIES, BATHTUBS, SHOWERS, BIDES, LAUNDRY TUBS AND WASHING MACHINE OUTLETS SHALL BE PROVIDED WITH HOT AND COLD WATER AND CONNECTED TO AN APPROVED WATER SUPPLY. (R306.4)
- BATHTUB AND SHOWER FLOORS, WALLS ABOVE BATHTUBS WITH A SHOWERHEAD, AND SHOWER COMPARTMENTS SHALL BE FINISHED WITH A NONABSORBENT SURFACE. SUCH WALL SURFACES SHALL EXTEND TO A HEIGHT OF NOT LESS THAN 6 FEET ABOVE THE FLOOR. (R307.2)
- PROVIDE ULTRA LOW FLUSH WATER CLOSETS FOR ALL NEW CONSTRUCTION. EXISTING SHOWER HEADS AND TOILETS MUST BE ADAPTED FOR LOW WATER CONSUMPTION.
- UNIT SKYLIGHTS SHALL BE LABELED BY A LA CITY APPROVED LABELING AGENCY. USHC LABEL SHALL STATE THE APPROVED LABELING AGENCY NAME, PRODUCT DESIGNATION AND PERFORANCE GRADE RATING. (RESEARCH REPORT NOT REQUIRED) R308.6.9.
- PROVIDE 72 INCH HIGH NON-ABSORBENT WALL ADJACENT TO SHOWER AND APPROVED SHATTER-RESISTANT MATERIALS FOR SHOWER ENCLOSURE. (1210.2.3,2406.4.5,R307.2,R308.4)
- WATER HEATER MUST BE STRAPPED TO WALL (SEC. 507.3, LAPC).
- AUTOMATIC GARAGE DOOR OPENERS, IF PROVIDED, SHALL BE LISTED IN ACCORDANCE WITH UL
- SMOKE DETECTORS SHALL BE PROVIDED FOR ALL DWELLING UNITS INTENDED FOR HUMAN OCCUPANCY, WHERE A PERMIT IS REQUIRED FOR ALTERATIONS, REPAIRS, OR ADDITIONS (R314.2)
- WHERE A PERMIT IS REQUIRED FOR ALTERATIONS, REPAIRS OR ADDITIONS, EXISTING DWELLINGS SLEEPING UNITS THAT HAVE ATTACHED GARAGES OR FUEL-BURNING APPLIANCES SHALL BE PROVIDED WITH A CARBON MONOXIDE ALARM IN ACCORDANCE WITH SECTION R315.2. CARBON MONOXIDE ALARMS SHALL BE REQUIRED IN THE SPECIFIC DWELLING UNIT OR SLEEPING UNIT FOR WHICH THE PERMIT WAS OBTAINED. (R315.2)
- EVERY SPACE INTENDED FOR HUMAN OCCUPANCY SHALL BE PROVIDED WITH NATURAL LIGHT BY MEANS OF EXTERIOR GLAZED OPENINGS IN ACCORDANCE WITH SECTION 303.1 OR SHALL BE PROVIDED WITH ARTIFICIAL LIGHT THAT IS ADEQUATE TO PROVIDE AN AVERAGE ILLUMINATION OF 6 FOOT-CANDLES OVER THE AREA OF THE ROOM AT A HEIGHT OF 30 INCHES ABOVE FLOOR LEVEL.
- A COPY OF THE EVALUATION REPORT AND/OR CONDITIONS OF LISTING SHALL BE MADE AVAILABLE AT THE JOB SITE.
- . OBTAIN PERMITS FROM PUBLIC WORKS PRIOR TO CONSTRUCTION FOR: W.A. TEMPORARY PEDESTRIAN PROTECTION AS REQUIRED BY LABC SECTION 303.7. FOR ANY CONSTRUCTION NEAR ANY STREET OR PUBLIC AREA.
- OUTLETS ALONG WALL COUNTER SPACE, ISLAND AND PENINSULA COUNTER SPACE IN KITCHENS SHALL HAVE A MAXIMUM SPACING OF 48". (210-52 NEC).
- THE FIRST LIGHT IN NEW AND REMODELED BATHROOMS AND KITCHENS SHALL BE AN ENERGY EFFICIENT LIGHT MEETING A MINIMUM OF 40 LUMENS OR WATT (E.G. FLUORESCENT LAMP). (T-24, SEC. 130(b) & 150(k)).
- BUILDINGS SHALL HAVE APPROVED ADDRESS NUMBERS, BUILDING NUMBERS OR APPROVED BUILDING IDENTIFICATION PLACED IN A POSITION THAT IS PLAINLY LEGIBLE AND VISIBLE FROM THE STREET OR ROAD FRONTING THE PROPERTY. (R319)
- VA. A COPY OF THE EVALUATION REPORT AND/OR CONDITIONS OF LISTING SHALL BE MADE AVAILABLE AT THE JOB SITE

- DOORS BETWEEN GARAGE AND THE DWELLING UNIT SHALL BE SELF-CLOSING AND SELF-LATCHING, SOLID WOOD OR SOLID HONEYCOMB CORE STEEL NOT LESS THAN 1-3/8" THICK, OR HAVE A MINIMUM FIRE PROTECTION RATING OF 20 MINUTES. (R302.5.1)
- B. THE GARAGE SHALL BE SEPARATED FROM THE DWELLING AND ITS ATTIC AREA IN ACCORDANCE WITH TABLE R302.6. (R302.6)
- DUCTS PENETRATING THE WALLS OR CEILINGS SEPARATING THE DWELLING FROM THE GARAGE SHALL BE CONSTRUCTED OF A MINIMUM OF NO. 26 GAGE SHEET STEEL OR OTHER APPROVED METRICAL AND THERE SHALL BE NO OPENINGS FROM THE DUCTS INTO THE GARAGE. (R302.5.2)
- OTHER PENETRATIONS OF GARAGE/DWELLING CEILINGS AD WALLS ARE TO BE PROTECTED AS REQUIRED BY SECTION R302.11, ITEM 4 (R302.5.3).
- GARAGE FLOOR SURFACE SHALL BE OF AN APPROVED NONCOMBUSTIBLE MATERIAL, AND THE AREA USED TO PARK VEHICLES SHALL BE SLOPED TO A DRAIN OR TOWARDS THE MAIN VEHICLE ENTRY. (R 309.1)

MEANS OF EGRESS:

- ENCLOSED ACCESSIBLE SPACE UNDER STAIRS SHALL HAVE WALLS, UNDER-STAIR SURFACE AND ANY SOFFITS PROTECTED ON THE ENCLOSED SIDE WITH 1/2 INCH GYPSUM BOARD. (R302.7)
- B. ALL INTERIOR AN EXTERIOR STAIRWAYS SHALL BE ILLUMINATED. (R303.6)
- PROVIDE 32" WIDE DOORS TO ALL INTERIOR ACCESSIBLE ROOMS WITHIN A DWELLING UNIT.
- PROVIDE EMERGENCY EGRESS FROM SLEEPING ROOMS AND BASEMENTS. MIN. 24" CLEAR HT, 20" CLEAR WIDTH, 5.7 SQ, FT, MIN, AREA.

INTERIOR ENVIRONMENT:

- A. BATHROOMS, WATER COLSET COMPARTMENTS AND OTEHR SIMILAR ROOMS SHALL BE PROVIED NATURAL VENTILATION OR WITH MECHANICAL VENTILATION CAPABLE OF 50 CFM EXHAUSTED DIRECTLY TO THE OUTSIDE. (R303.3)
- HEATER SHALL BE CAPABLE OF MAINTAINING A MINIMUM ROOM TEMPERATURE OF 60° F AT A POINT 3 FEET ABOVE THE FLOOR AND 2 FEET FROM EXTERIOR WALLS IN ALL HABITABLE ROOMS AT THE DESIGN TEMPERATURE. (R303.8)

FIRE-RESISTANT RATED CONSTRUCTION:

- A. IN COMBUSTIBLE CONSTRUCTION, FIRE BLOCKING SHALL BE PROVIDED TO CUT OFF ALL CONCEALED DRAFT OPENINGS (BOTHVERTICAL AND HORIZONTAL) AND TO FORM AN EFFECTIVE FIRE BARRIER BETWEEN STORIES, BETWEEN A TOP STORY AND THE ROOF SPACE. (R302.11).
- B. IN COMBUSTIBLE CONSTRUCTION WHERE THERE IS USABLE SPACE BOTH ABOVE AND BELOW THE CONCEALED SPACE OF A FLOOR/CEILING ASSEMBLY, DRAFTSTOPS SHALL BE INSTALLED SO THAT THE AREA OF THE CONCEALED SPACE DOES NOT EXCEED 1,000 SQUARE FEET. DRAFTSTOPPING SHALL DIVIDE THE CONCEALED SPACE INTO APPROXIMATELY EQUAL AREAS. (R302.12)
- FIRE BLOCKING MUST BE PROVIDED IN ACCORDANCE WITH SECTION 717 AT THE FOLLOWING
- C.A. IN CONCEALED SPACES OF STUD WALLS AND PARTITIONS, INCLUDING FURRED SPACES, A THE CEILING AND FLOOR LEVELS. C.B. IN CONCEALED SPACES OF STUD WALLS AND PARTITIONS, INCLUDING FURRED SPACES, AT
- 10-FOOT INTERVALS ALONG THE LENGTH OF THE WALL. C.C. AT ALL INTERCONNECTIONS BETWEEN CONCEALED VERTICAL AND HORIZONTAL SPACES SUCH
- AS OCCUR AT SOFFITS. DROP CEILINGS AND COVE CEILINGS. C.D. IN CONCEALED SPACES BETWEEN STAIR STRINGERS AT THE TOP AND BOTTOM OF THE RUN
- AND BETWEEN STUDS ALONG AND IN LINE WITH THE RUN OF STAIRS IF THE WALL UNDER THE STAIRS IS UNFINISHED.
- IN OPENINGS AROUND VENTS, PIPES, DUCTS, CHIMNEYS, FIREPLACES AND SIMILAR OPENINGS WHICH AFFORD A PASSAGE FOR FIRE AT CEILING AND FLOOR LEVELS. WITH NONCOMBUSTIBLE MATERIALS.

PROJECT TEAM:

BURBANK, CA 91506 C.818.434.2250 ARMEN@ARMENARC.COM



AS INSTRUMENT OF SERVICE, ALL DESIGN, IDEAS AND INFORMATION SHOWN ON THESE DRAWINGS ARE AND SHALL REMAIN THE PROPERTY OF THE CORPORATION ARMENARC. NO PART THEREOF SHALL BE COPIED, DISCLOSED TO OTHERS, OF USED IN CONNECTION WITH ANY WORK OR PROJECT OTHER PREPARED AND DEVELOPED WITHOUT THE WRITTEN CONSENT (
ARMENARC. VISUAL CONTACT WITH THESE DRAWINGS SHA
CONSTITUTE CONCLUSIVE EVIDENCE OF ACCEPTANCE OF THE
RESTRICTIONS.

PROPERTY OWNER: NERSES YARIJANYAN 7665 MACHREA ST. LOS ANGELES, CA 91042 (818) 406-1935 NERO-Y@INBOX.RU

CIVIL ENGINEER: TLC, TECHNA LAND CO, INC. HAYK MARTIROSIAN 1545 N. VERDUGO RD. #2 GLENDALE, CA 91208 (818) 547-0543

HAYK@TECHNALAND.COM

PROJECT TITLE:

MACHREA

PROJECT ADDRESS: 7665 MACHREA ST. LOS ANGELES, CA 91042

ISSUED FOR:


7 SMALL LOT SFR


DRAWN BY: CHECKED BY: | A.T. 07-13-23 DATE: SHEET DESCRIPTION:


PROJECT NOTES / FORMS


SHEET NUMBER:

JOB NO.:

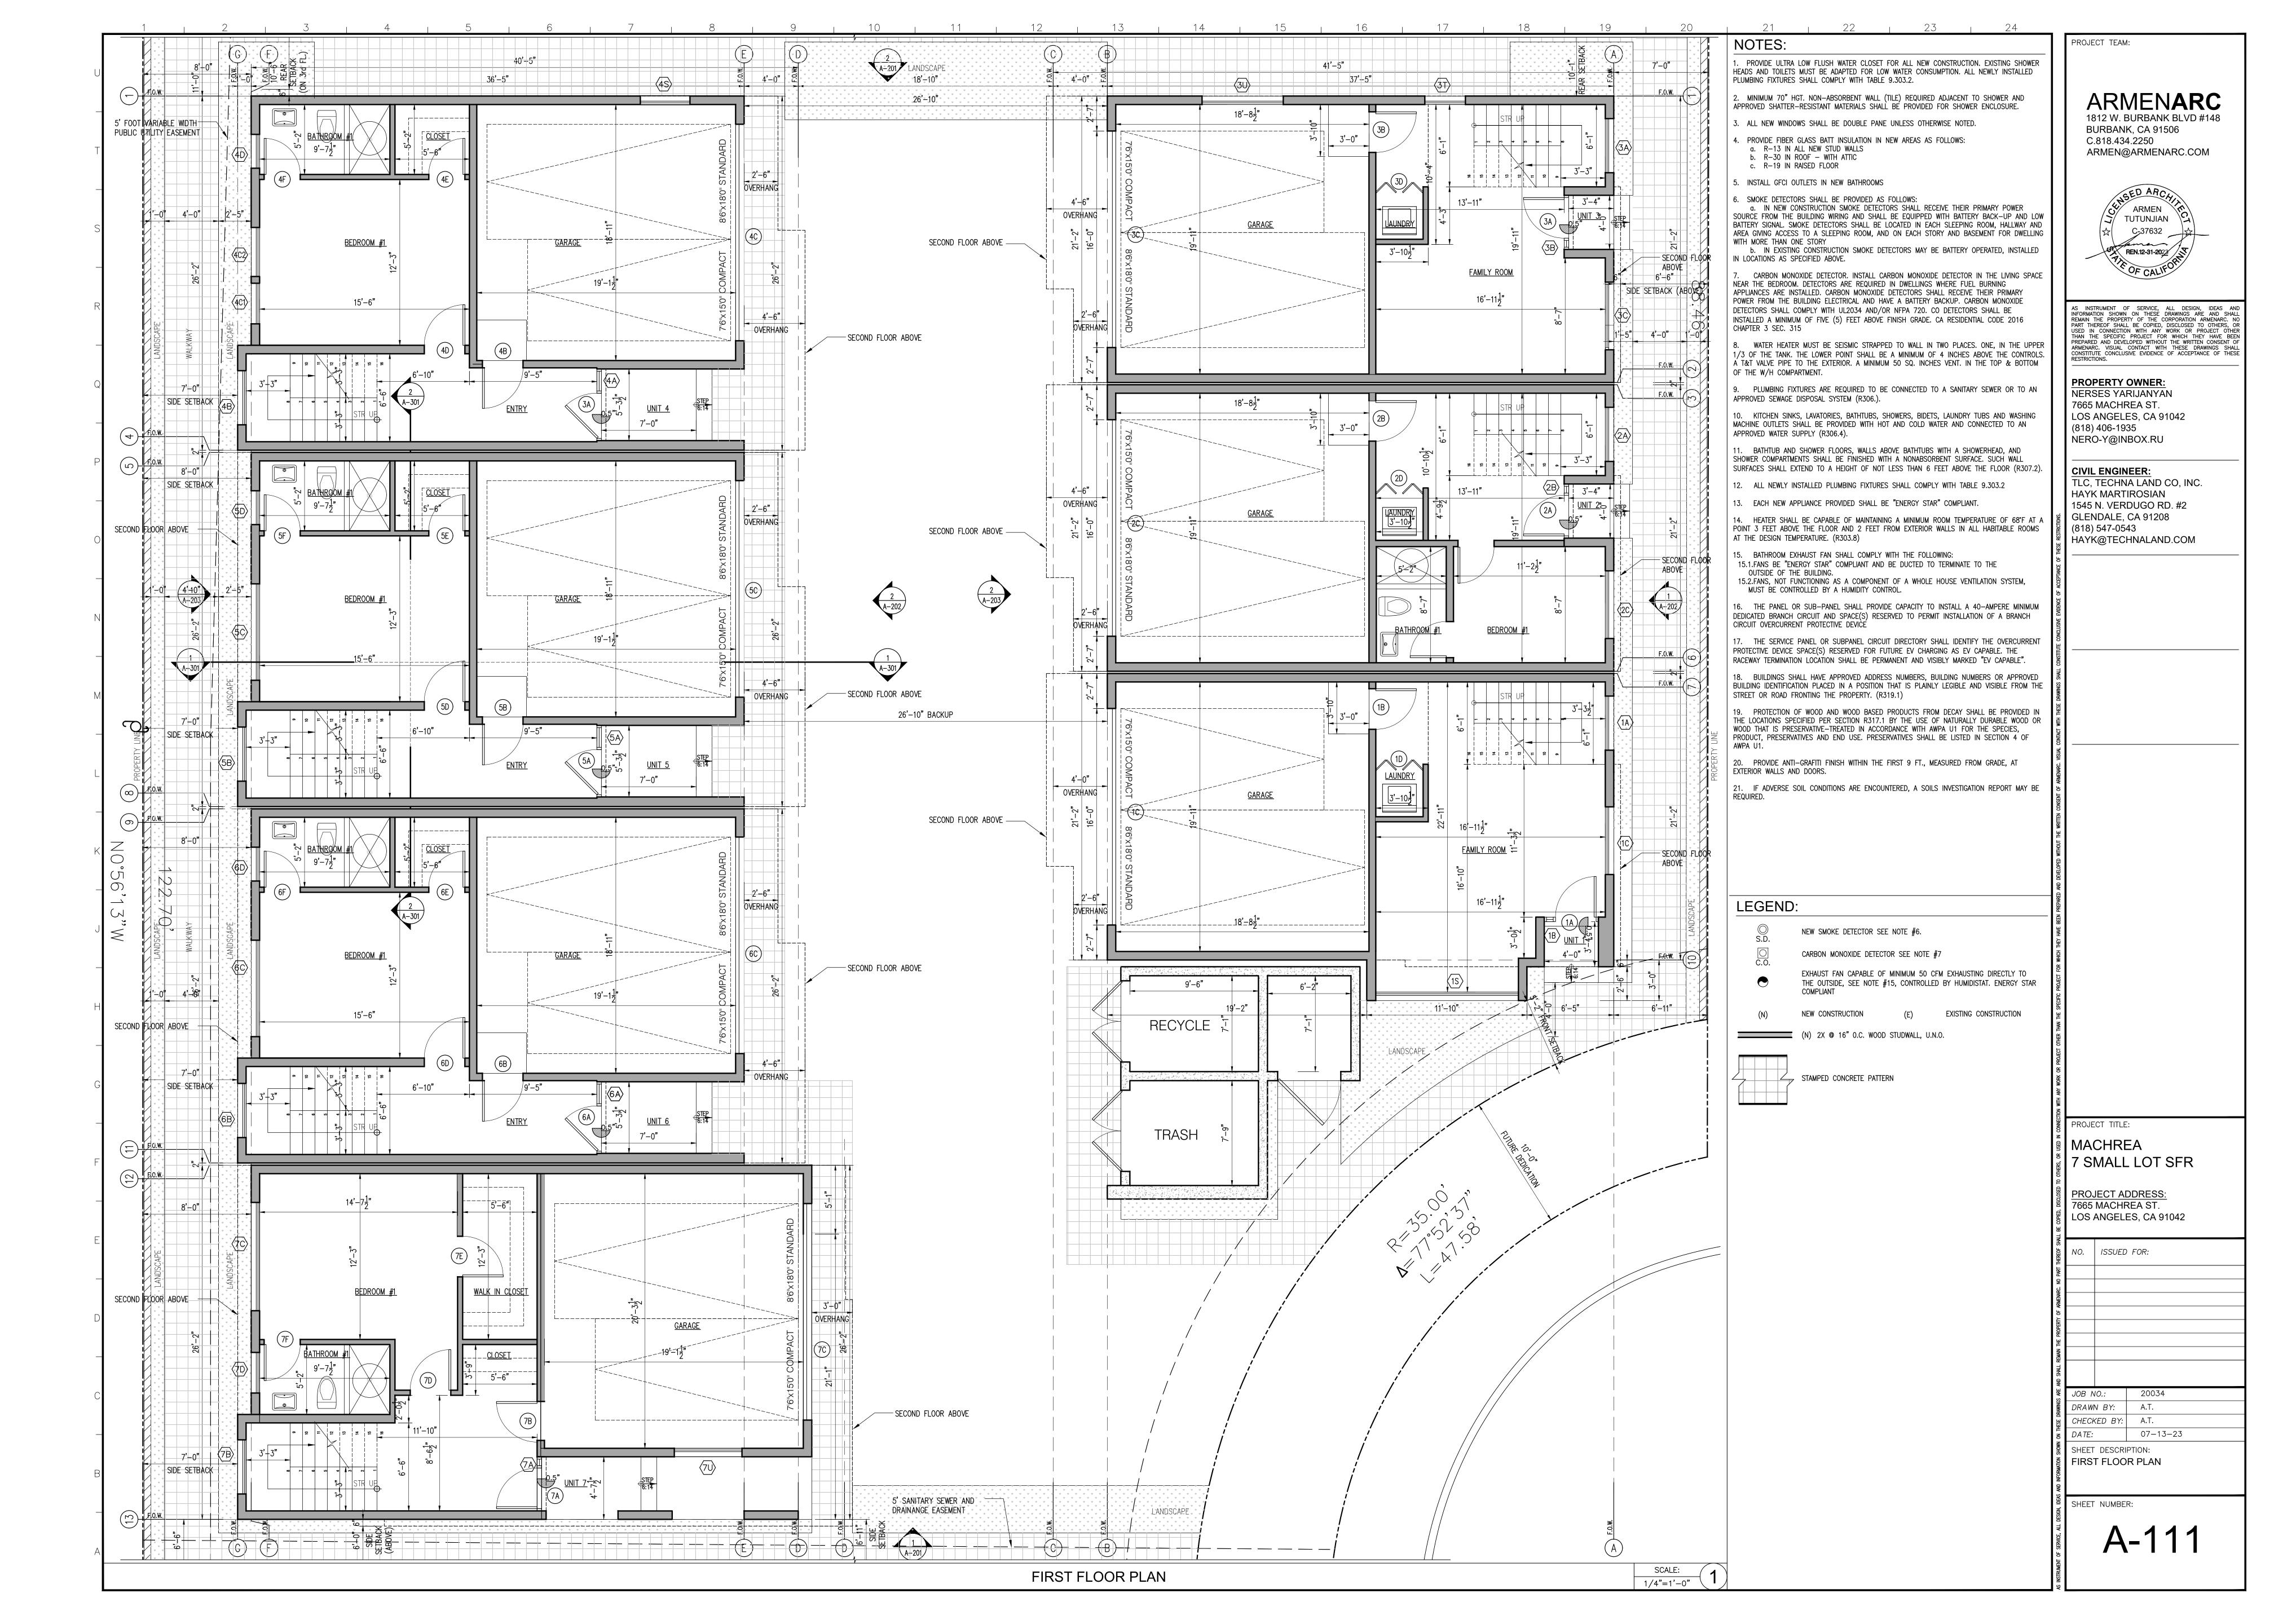

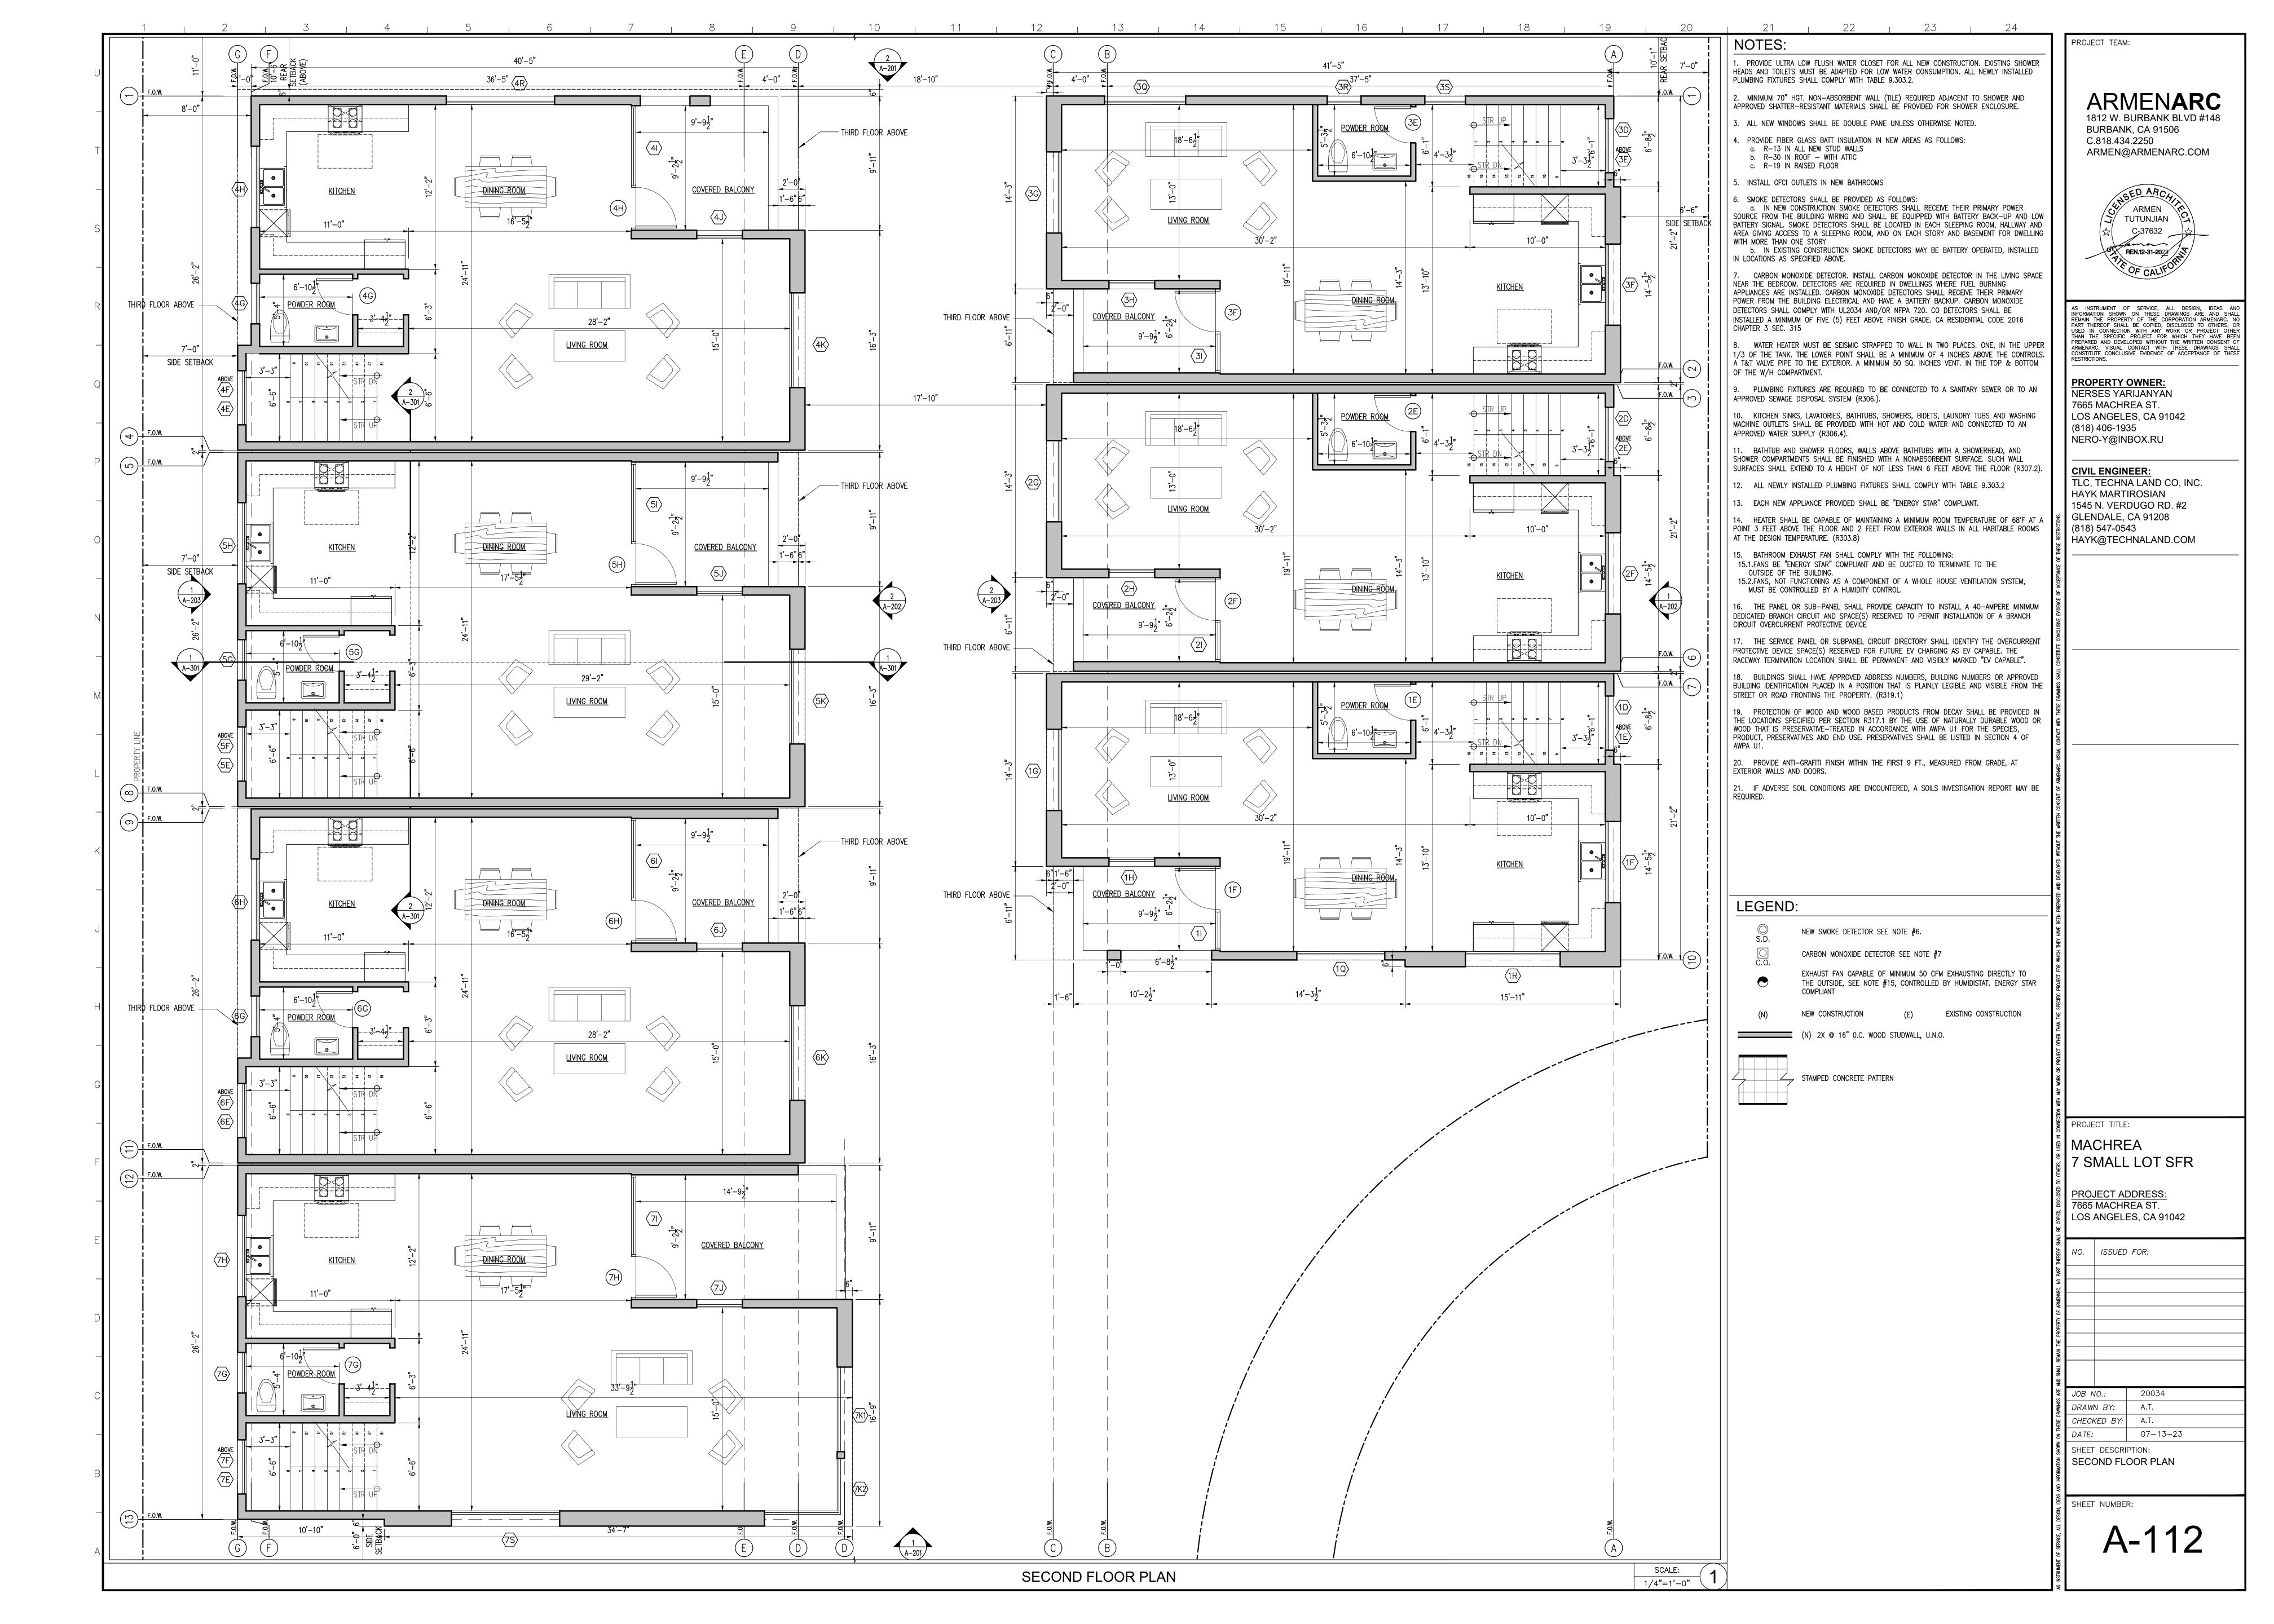

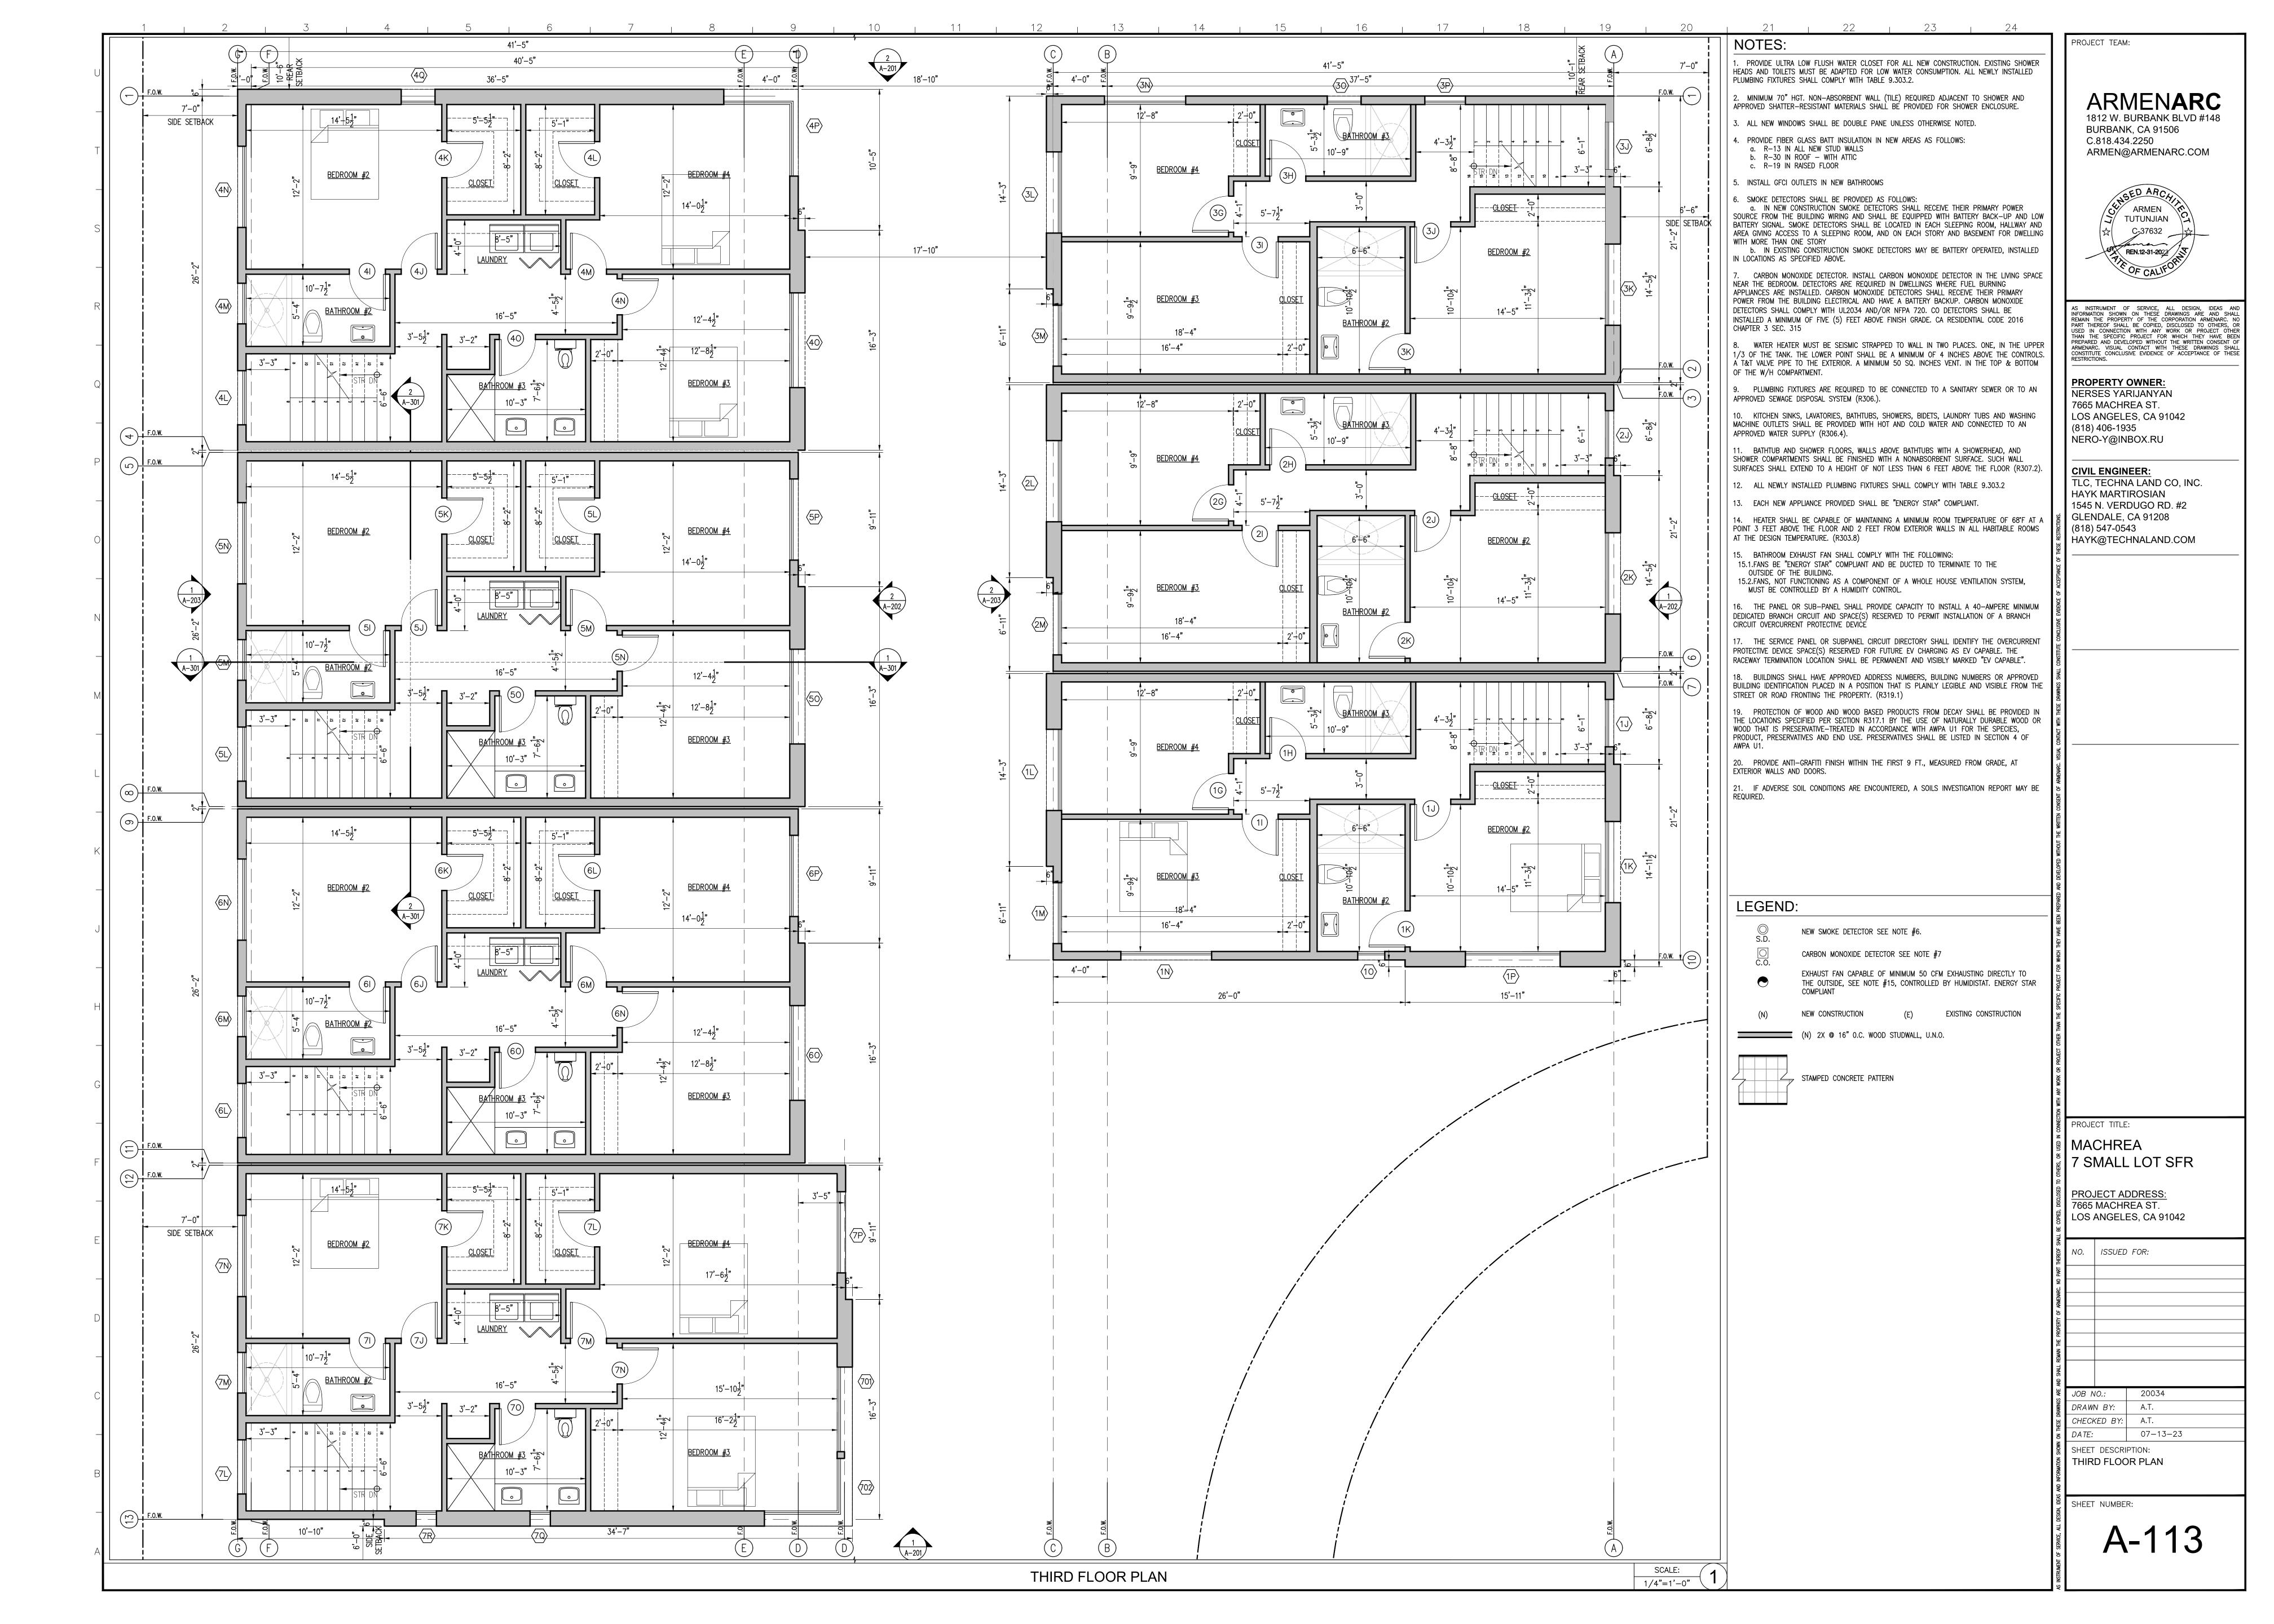


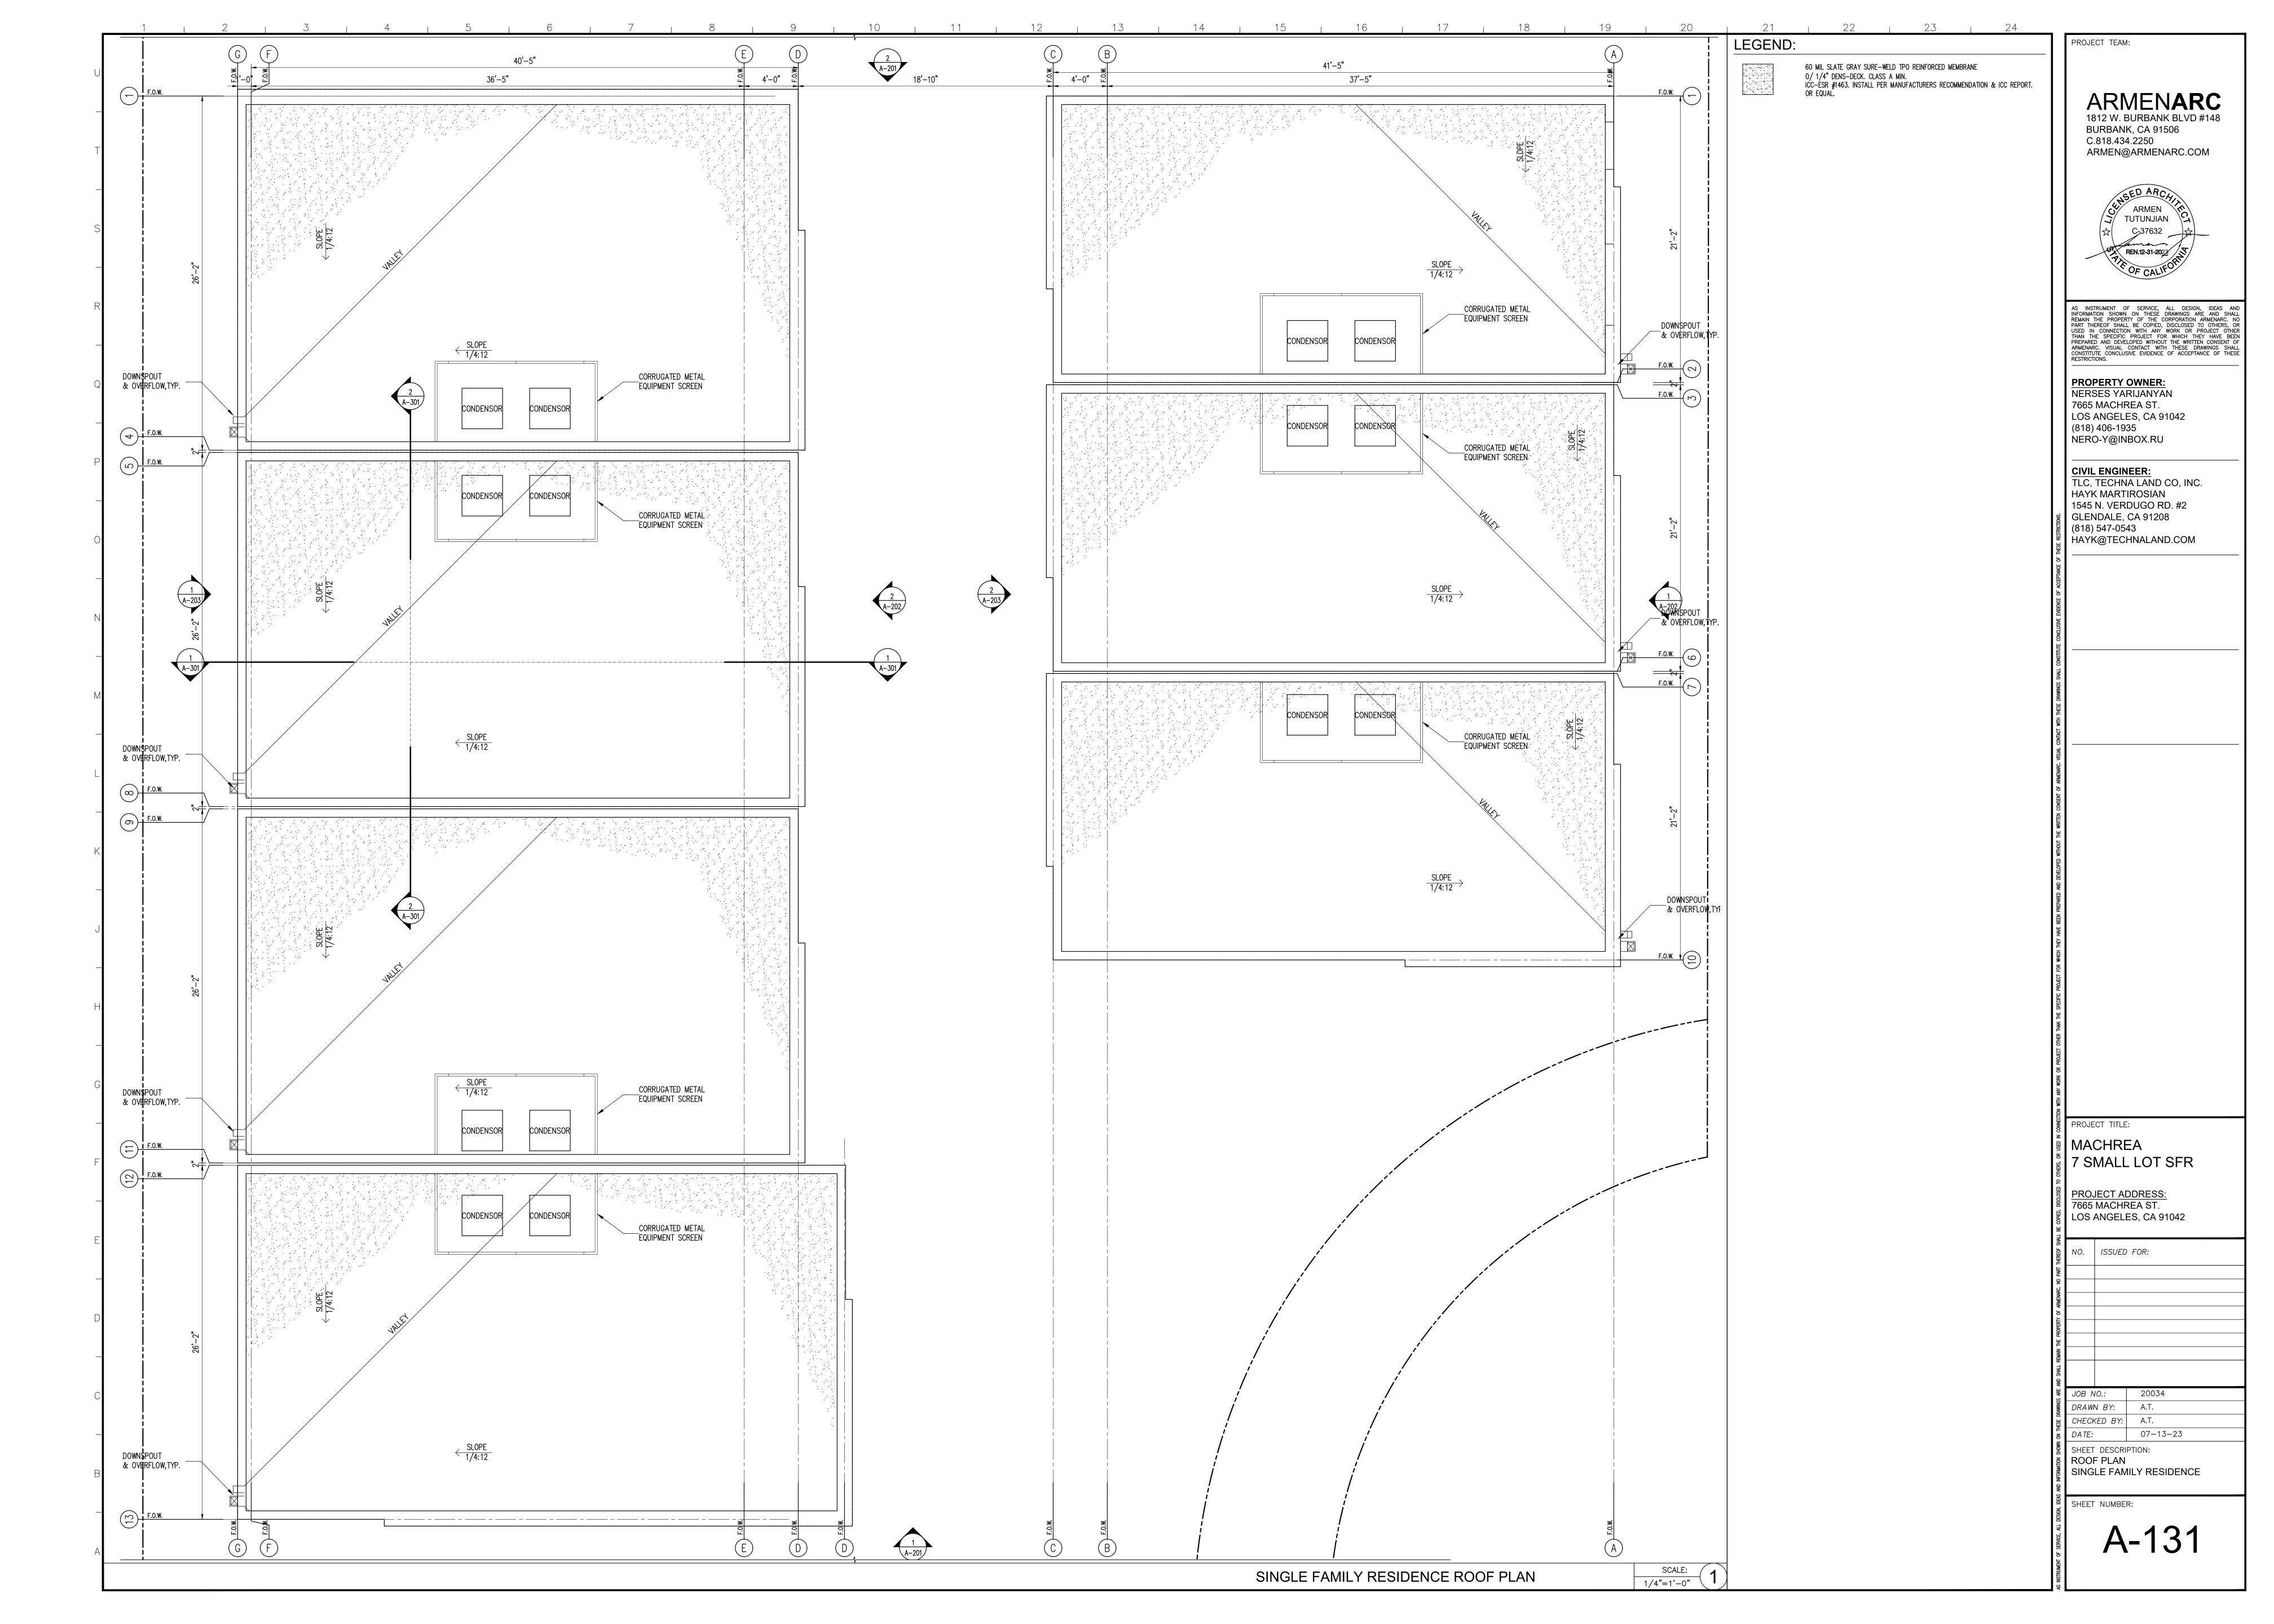








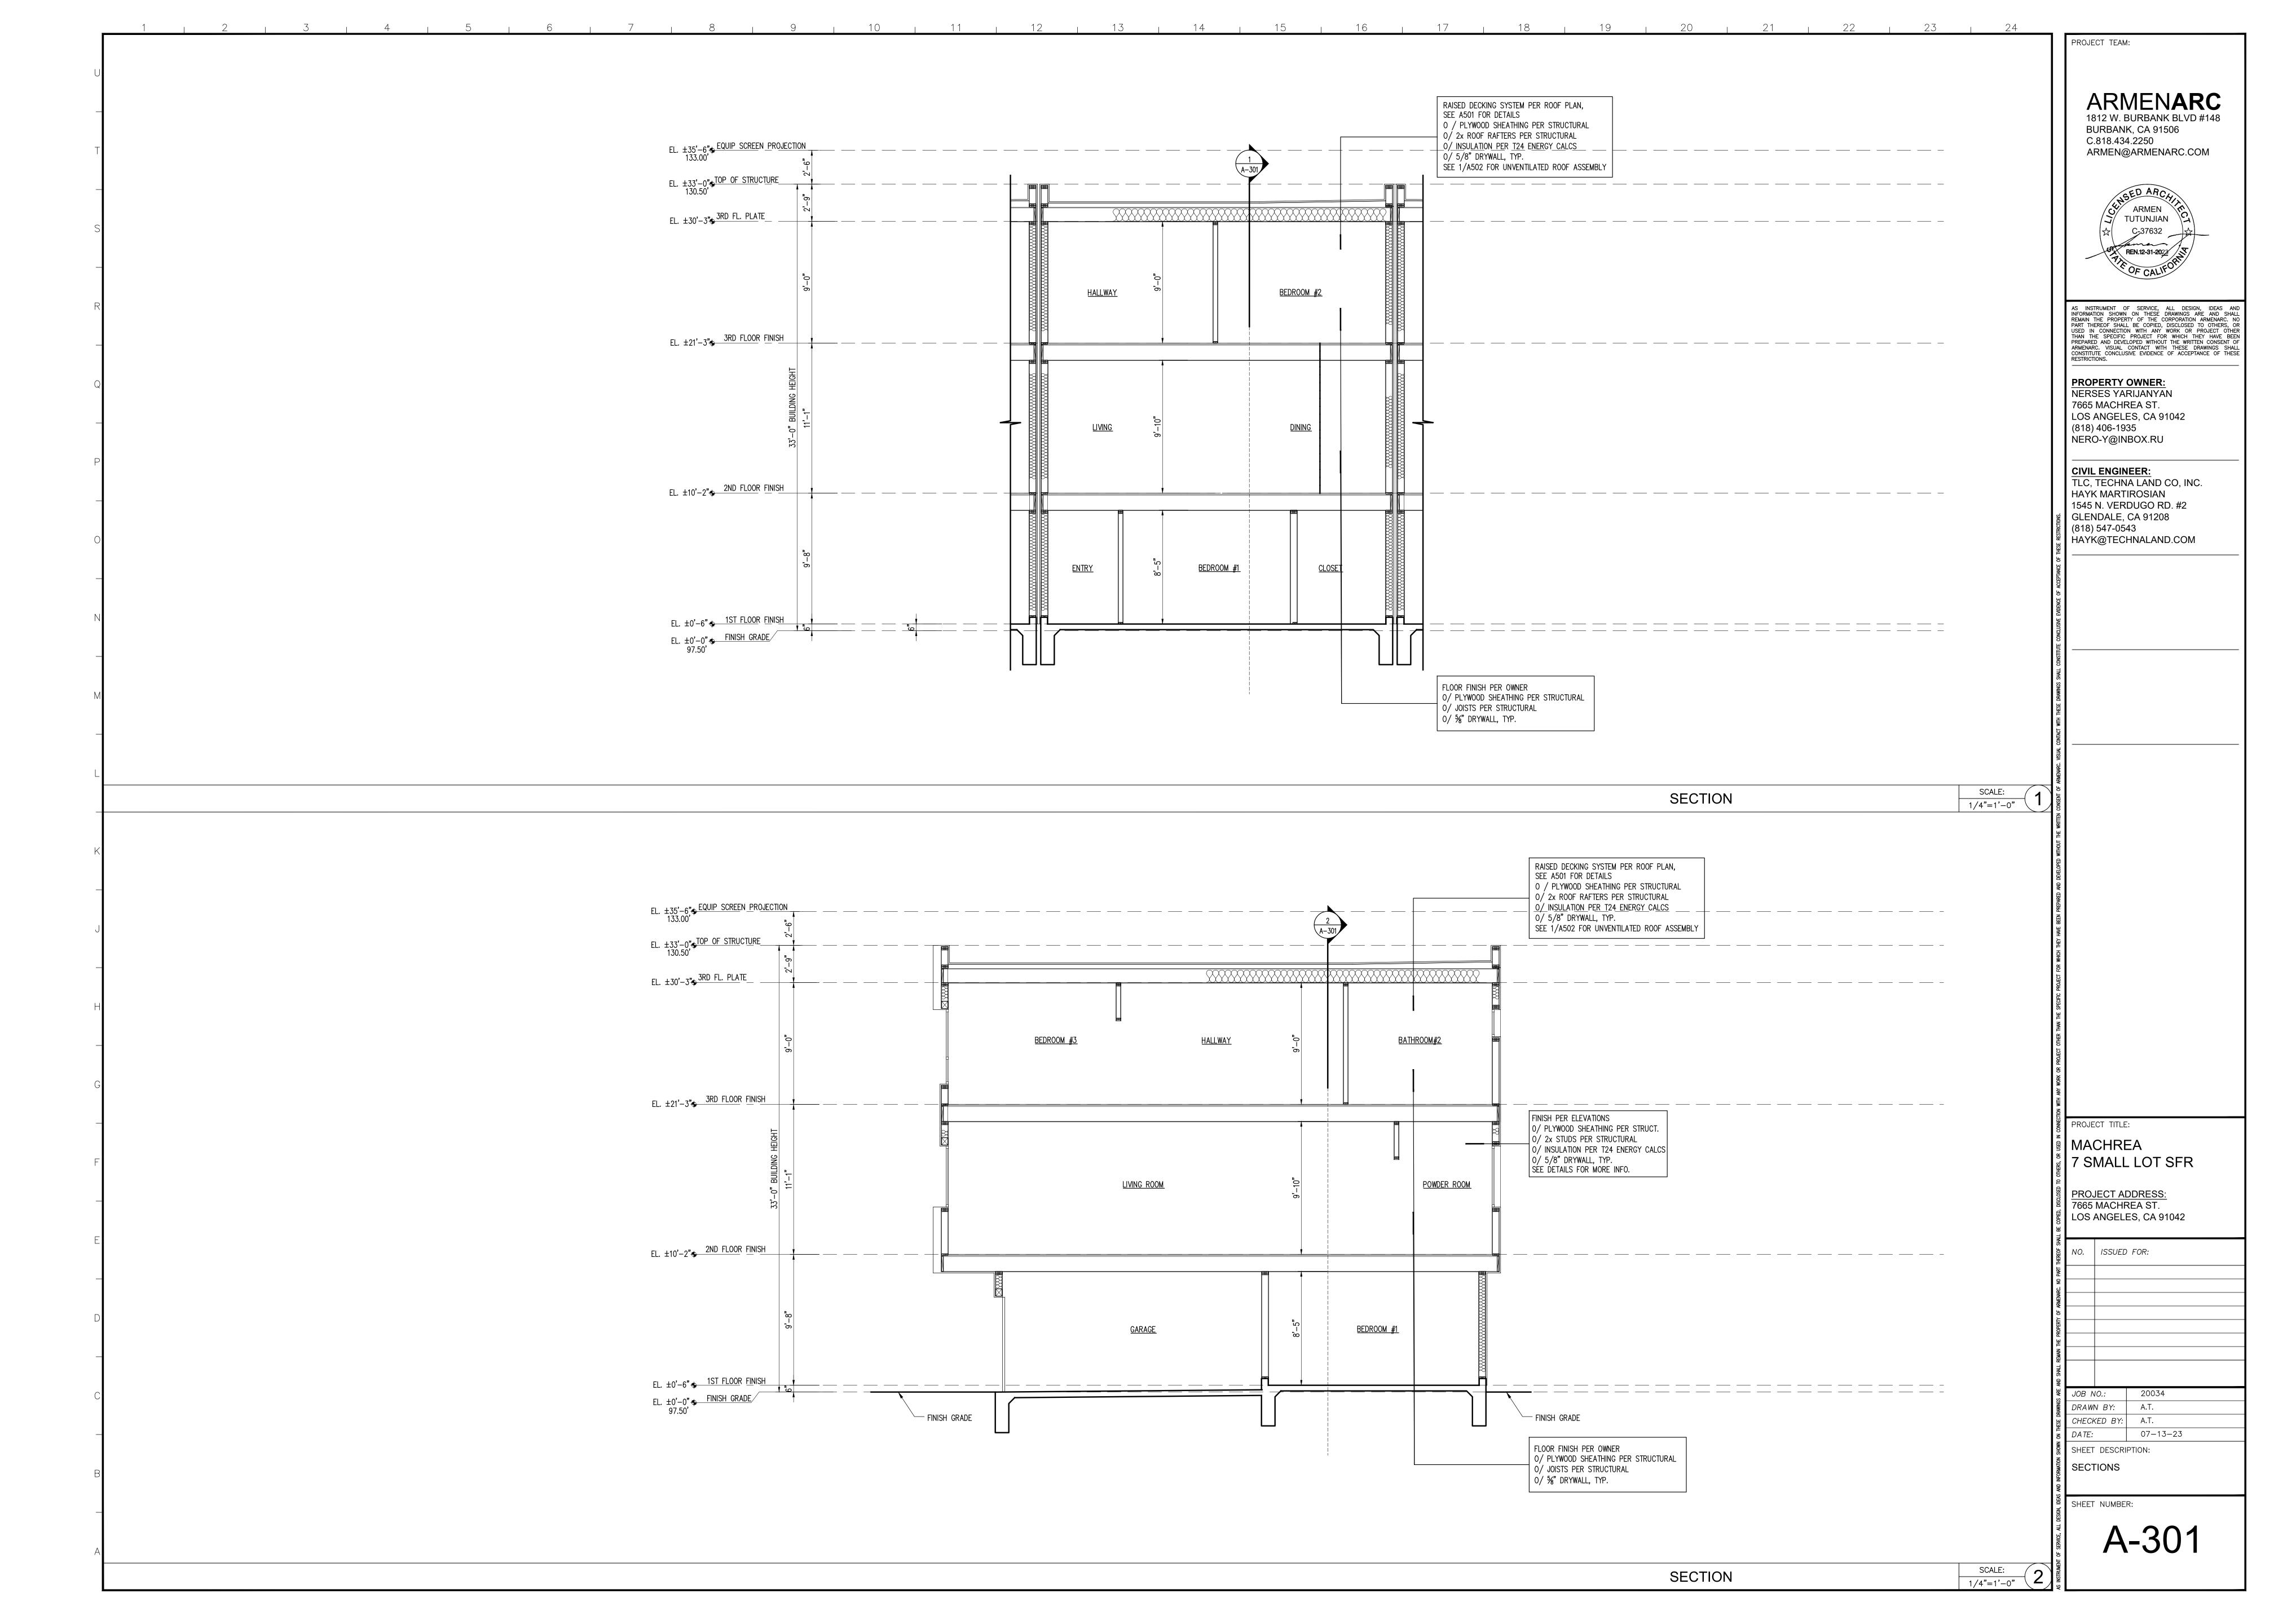

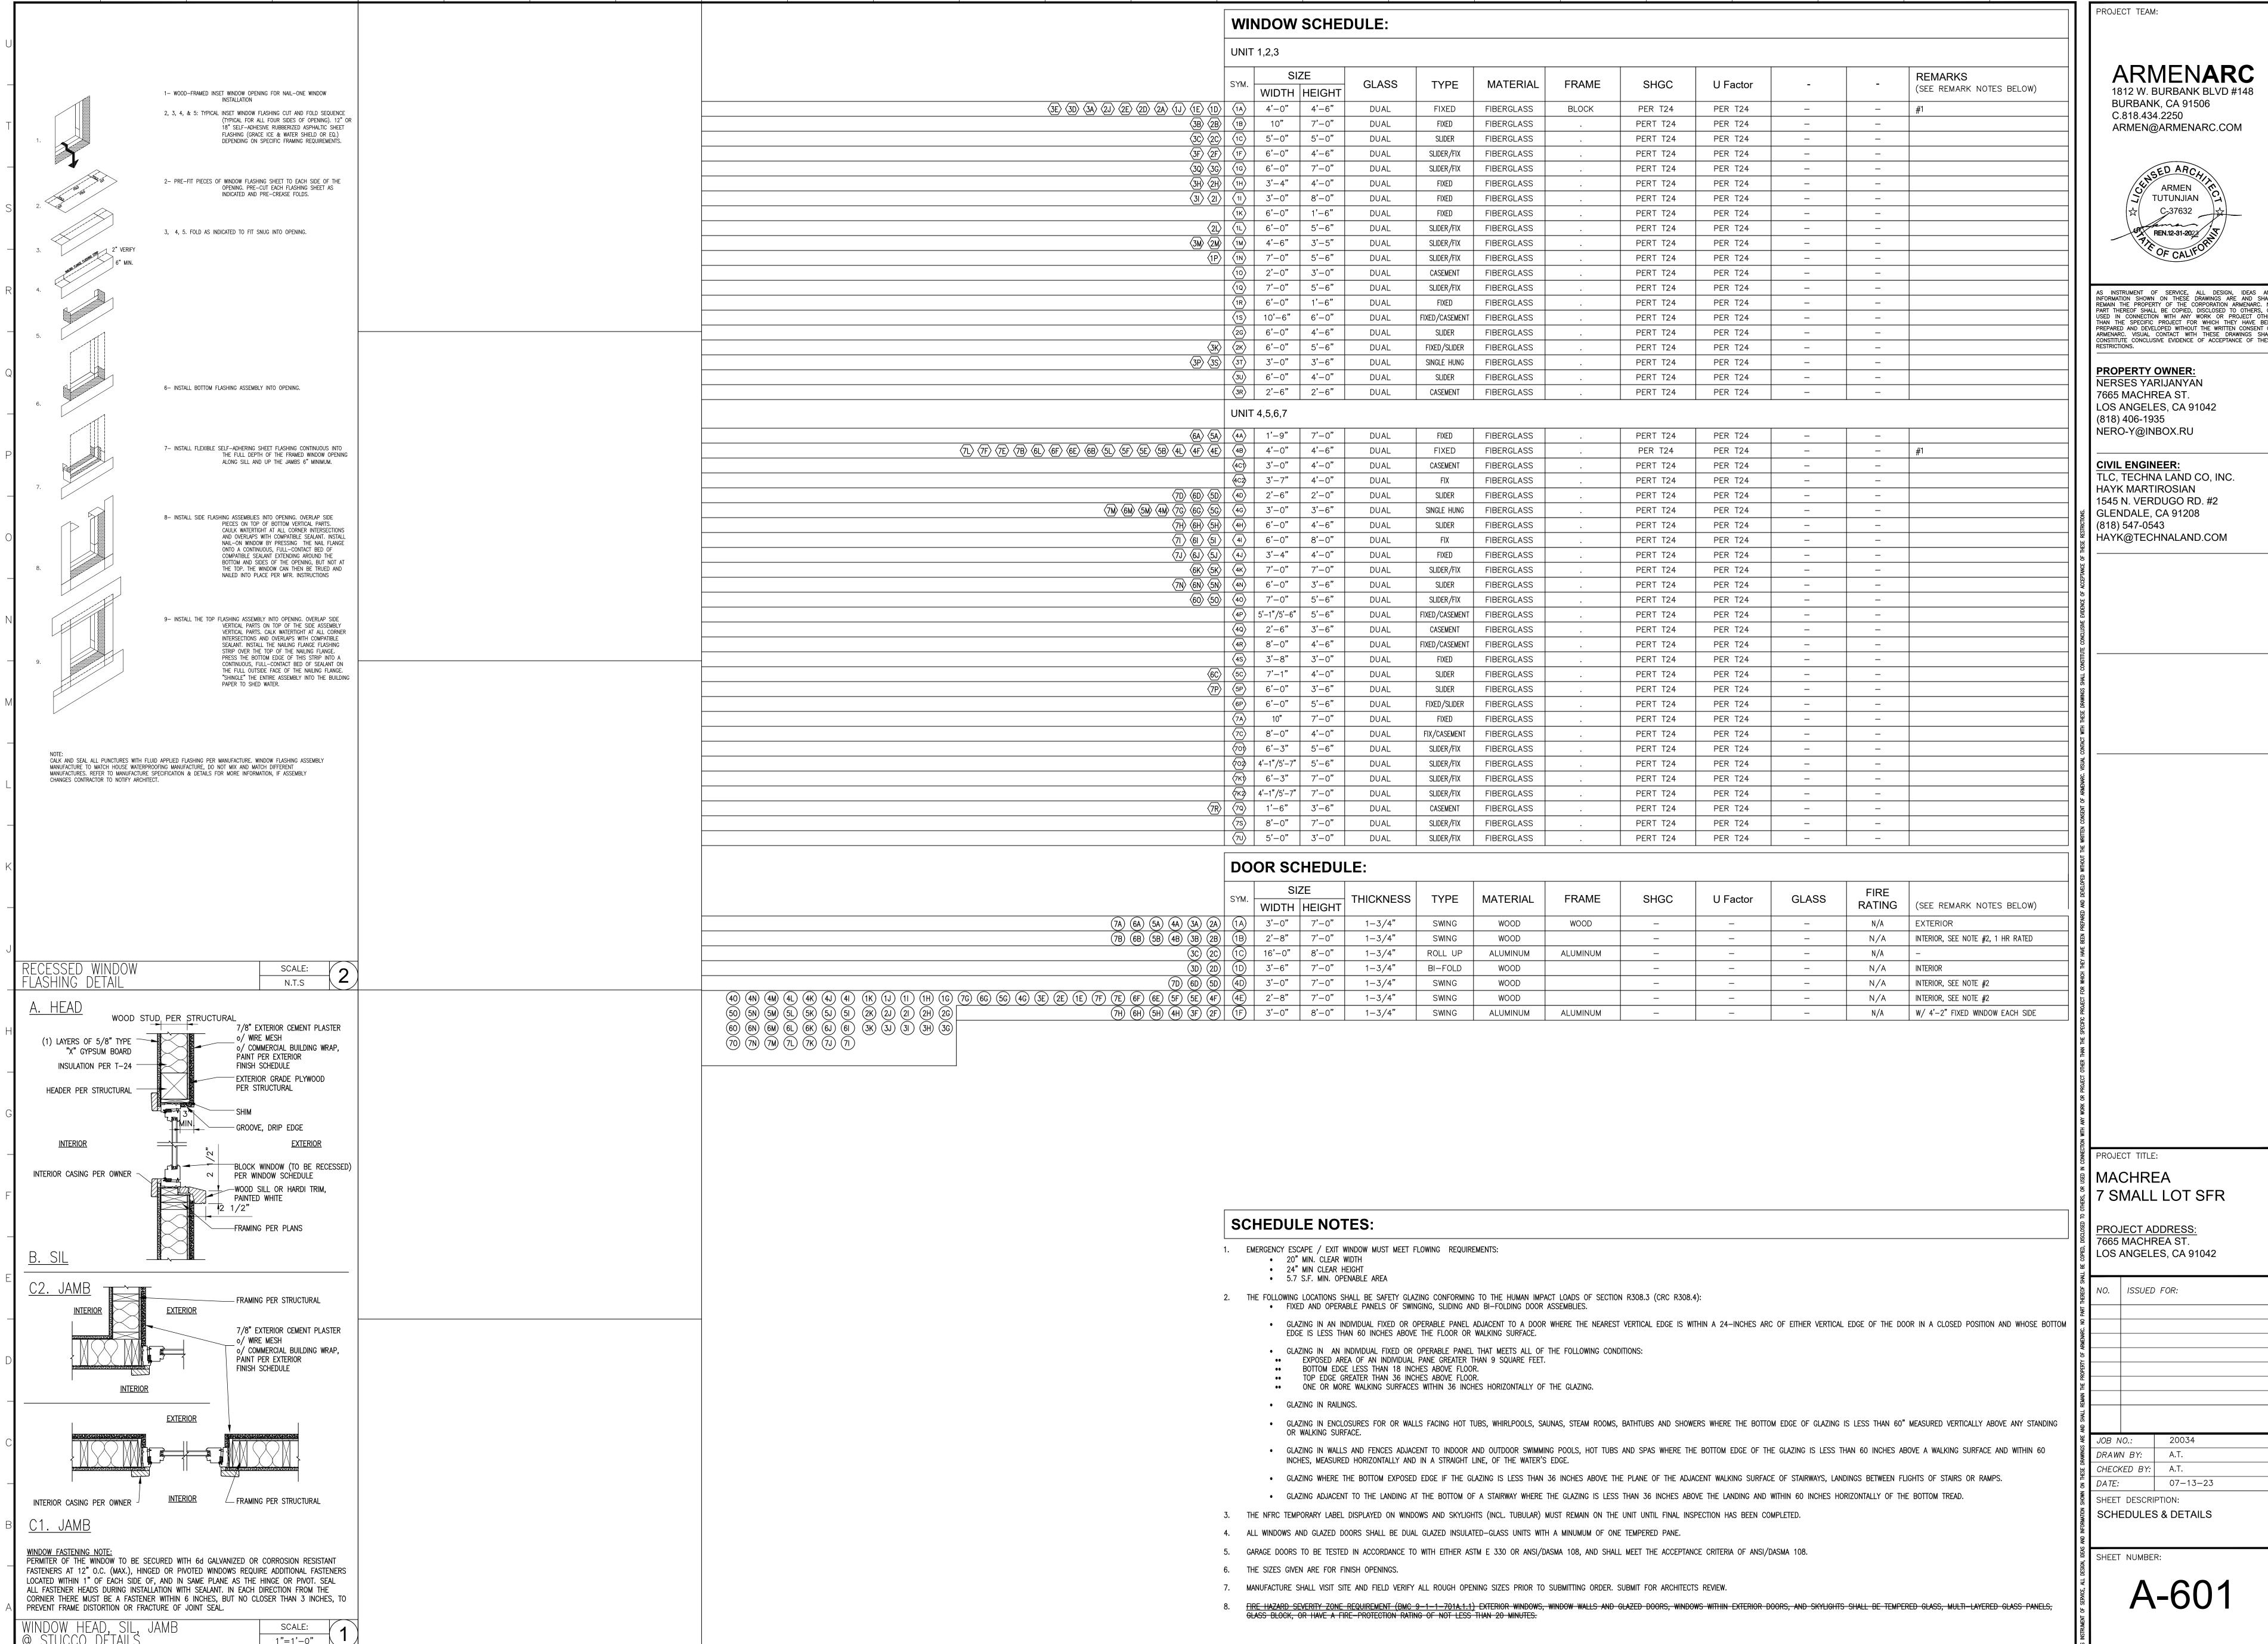

AS INSTRUMENT OF SERVICE, ALL DESIGN, IDEAS AND INFORMATION SHOWN ON THESE DRAWINGS ARE AND SHALL REMAIN THE PROPERTY OF THE CORPORATION ARMENARC. NO PART THEREOF SHALL BE COPIED, DISCLOSED TO OTHERS, OR USED IN CONNECTION WITH ANY WORK OR PROJECT OTHER THAN THE SPECIFIC PROJECT FOR WHICH THEY HAVE BEEN DREPARED AND DEVELOPED WITHOUT THE WRITTEN CONSENT OF

	THER				
	PART				
١	о <u>к</u>				
	ARE AND SHALL REMAIN THE PROPERTY OF ARMENARC. NO PART THER				
	OF A				
	OPERTY				
	HE PR				
	MAIN 1				
	ALL RE				
	AND SH				
	ARE /	JOB N	10.:	20034	